

KEYNOTES - REMODEL	
Keynote Number	Keynote Description
#	COORDINATE EXACT LOCATION OF ALL CEILING MOUNTED GRILLES AND DIFFUSERS WITH CEILING GRID, SPRINKLER HEADS, RECESSED LIGHTING AND ALL OTHER CEILING MOUNTED EQUIPMENT.
1	ELECTRICAL CONTRACTOR TO DISCONNECT UNIT AND RE CONNECT TO EXISTING ELECTRICAL CIRCUIT BACK TO SOURCE. TYPICAL THOUGHTOUT PROJECT.



HSR ASSOCIATES INC.
100 MILWAUKEE STREET
LA CROSSE, WISCONSIN
PHONE: 608.784.1830
FAX: 608.782.5844
www.hsrassociates.com

Consultant:

HOUSING AUTHORITY OF THE CITY OF LA CROSSE
2026 CAPITAL IMPROVEMENTS PROJECTS

Project Location: 1307 BADGER STREET
LA CROSSE, WI 54602

Sheet Title: FLOOR PLANS

HSR Project Number: 26039

Project Date: SEPT 24, 2026

Drawn By: JB/AB



Key Plan:

BID SET

Revisions:		
No.	Description	Date


Graphic Scale: 0 2 4 6 12

MEP210

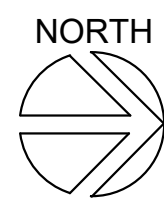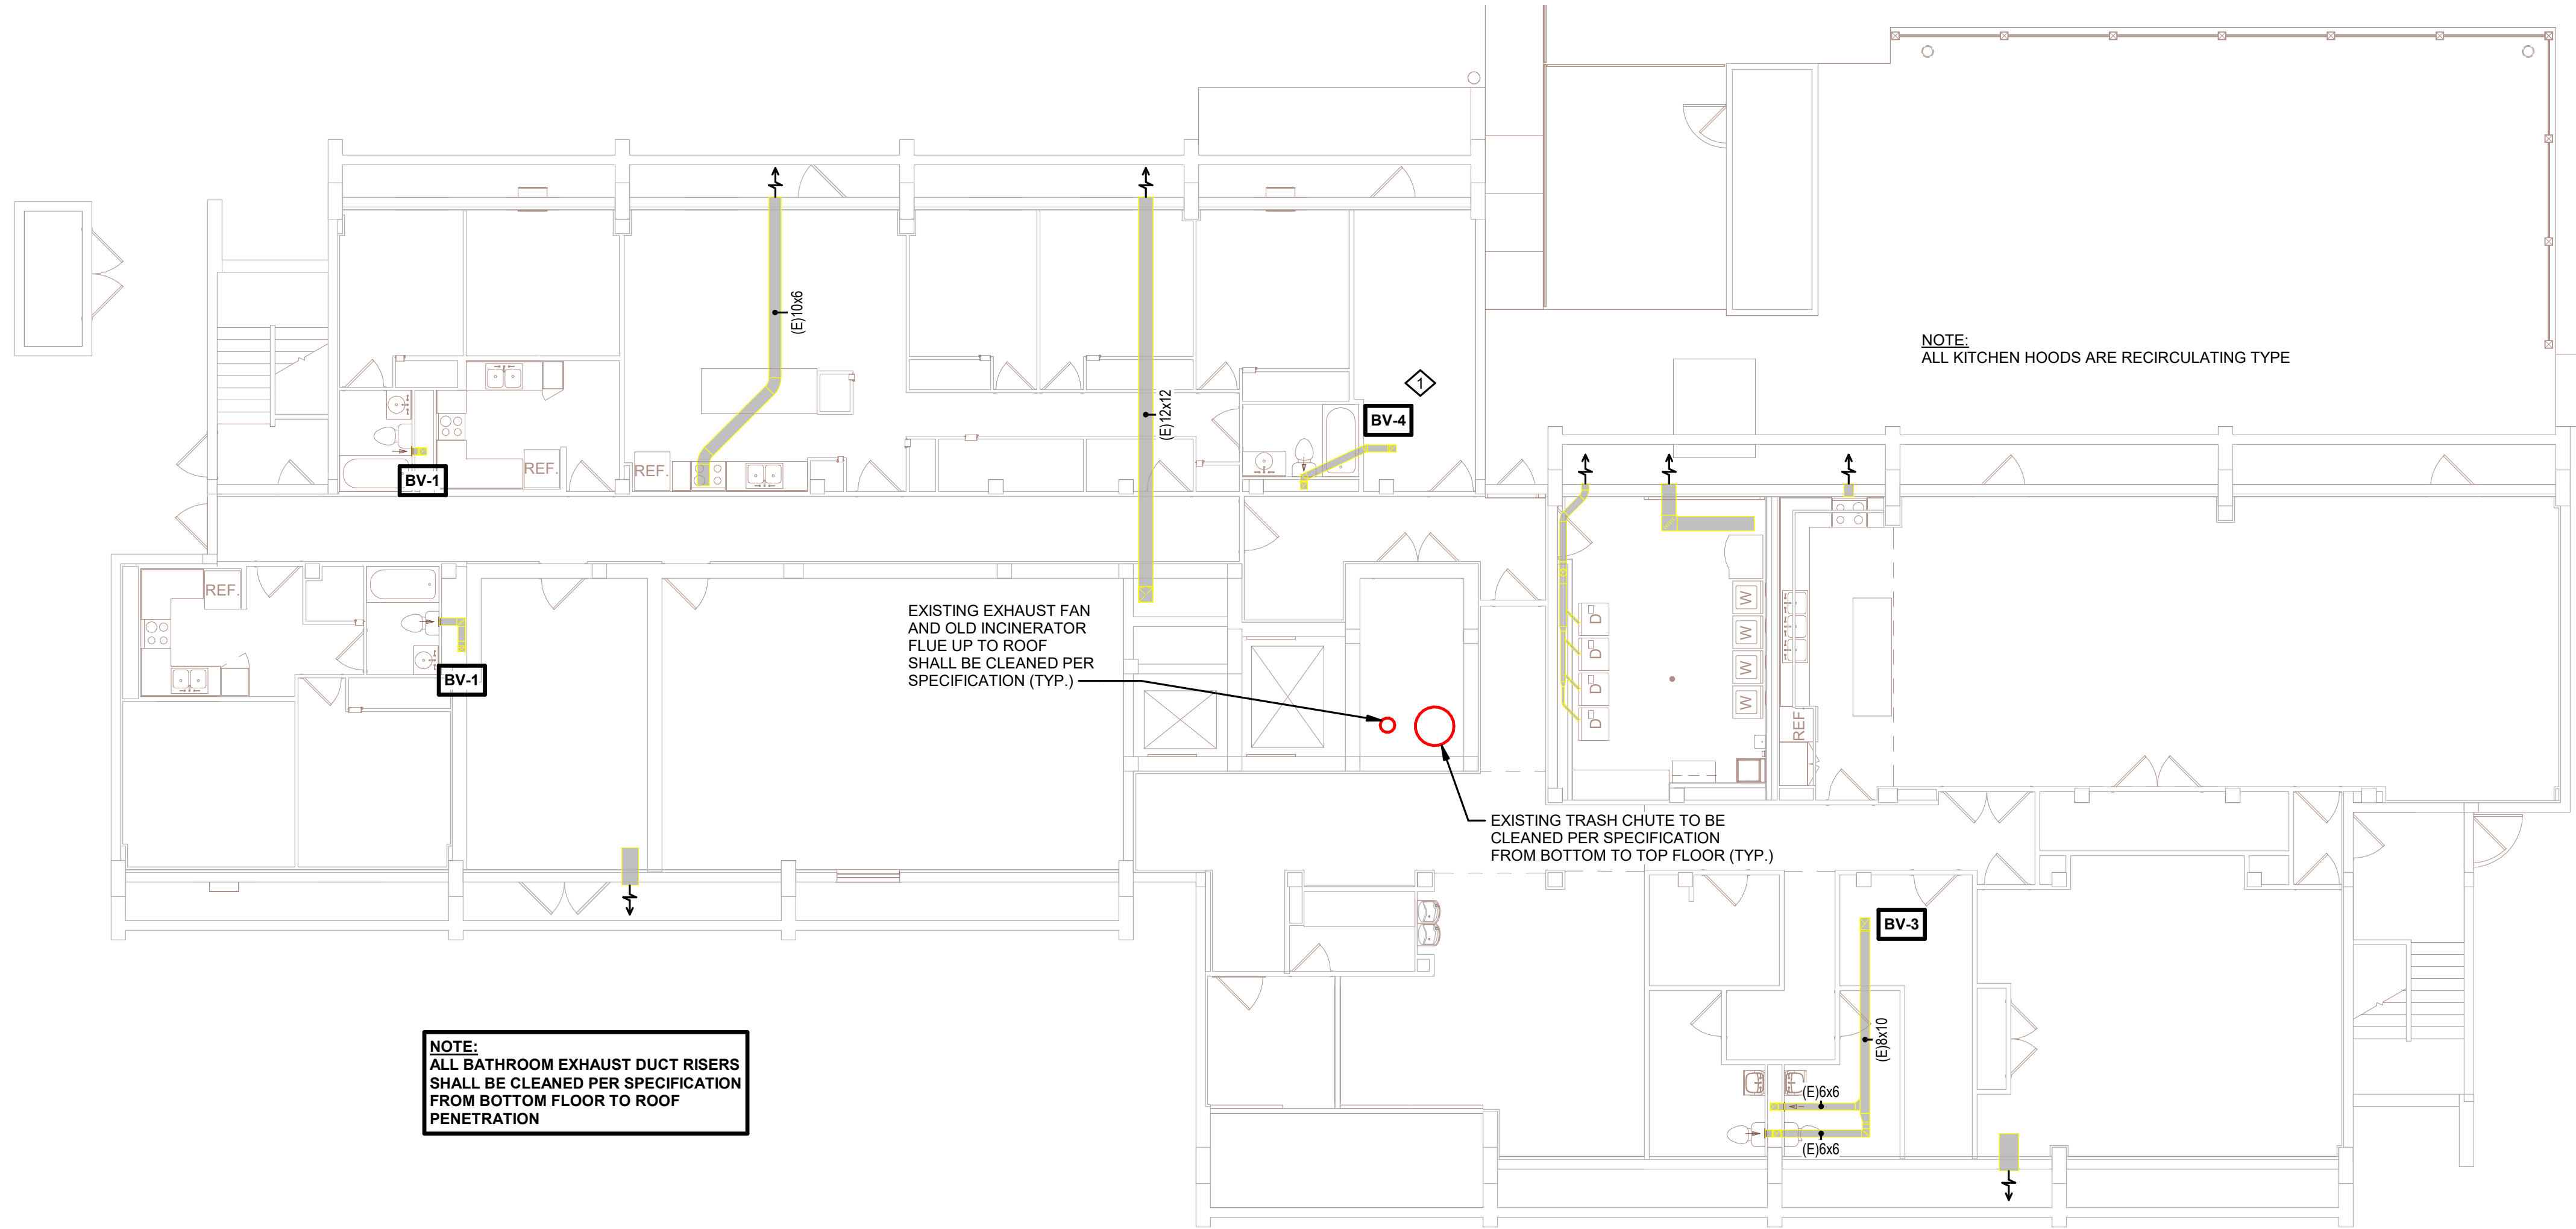


1 1ST FLOOR HVAC

1/8" = 1'-0"

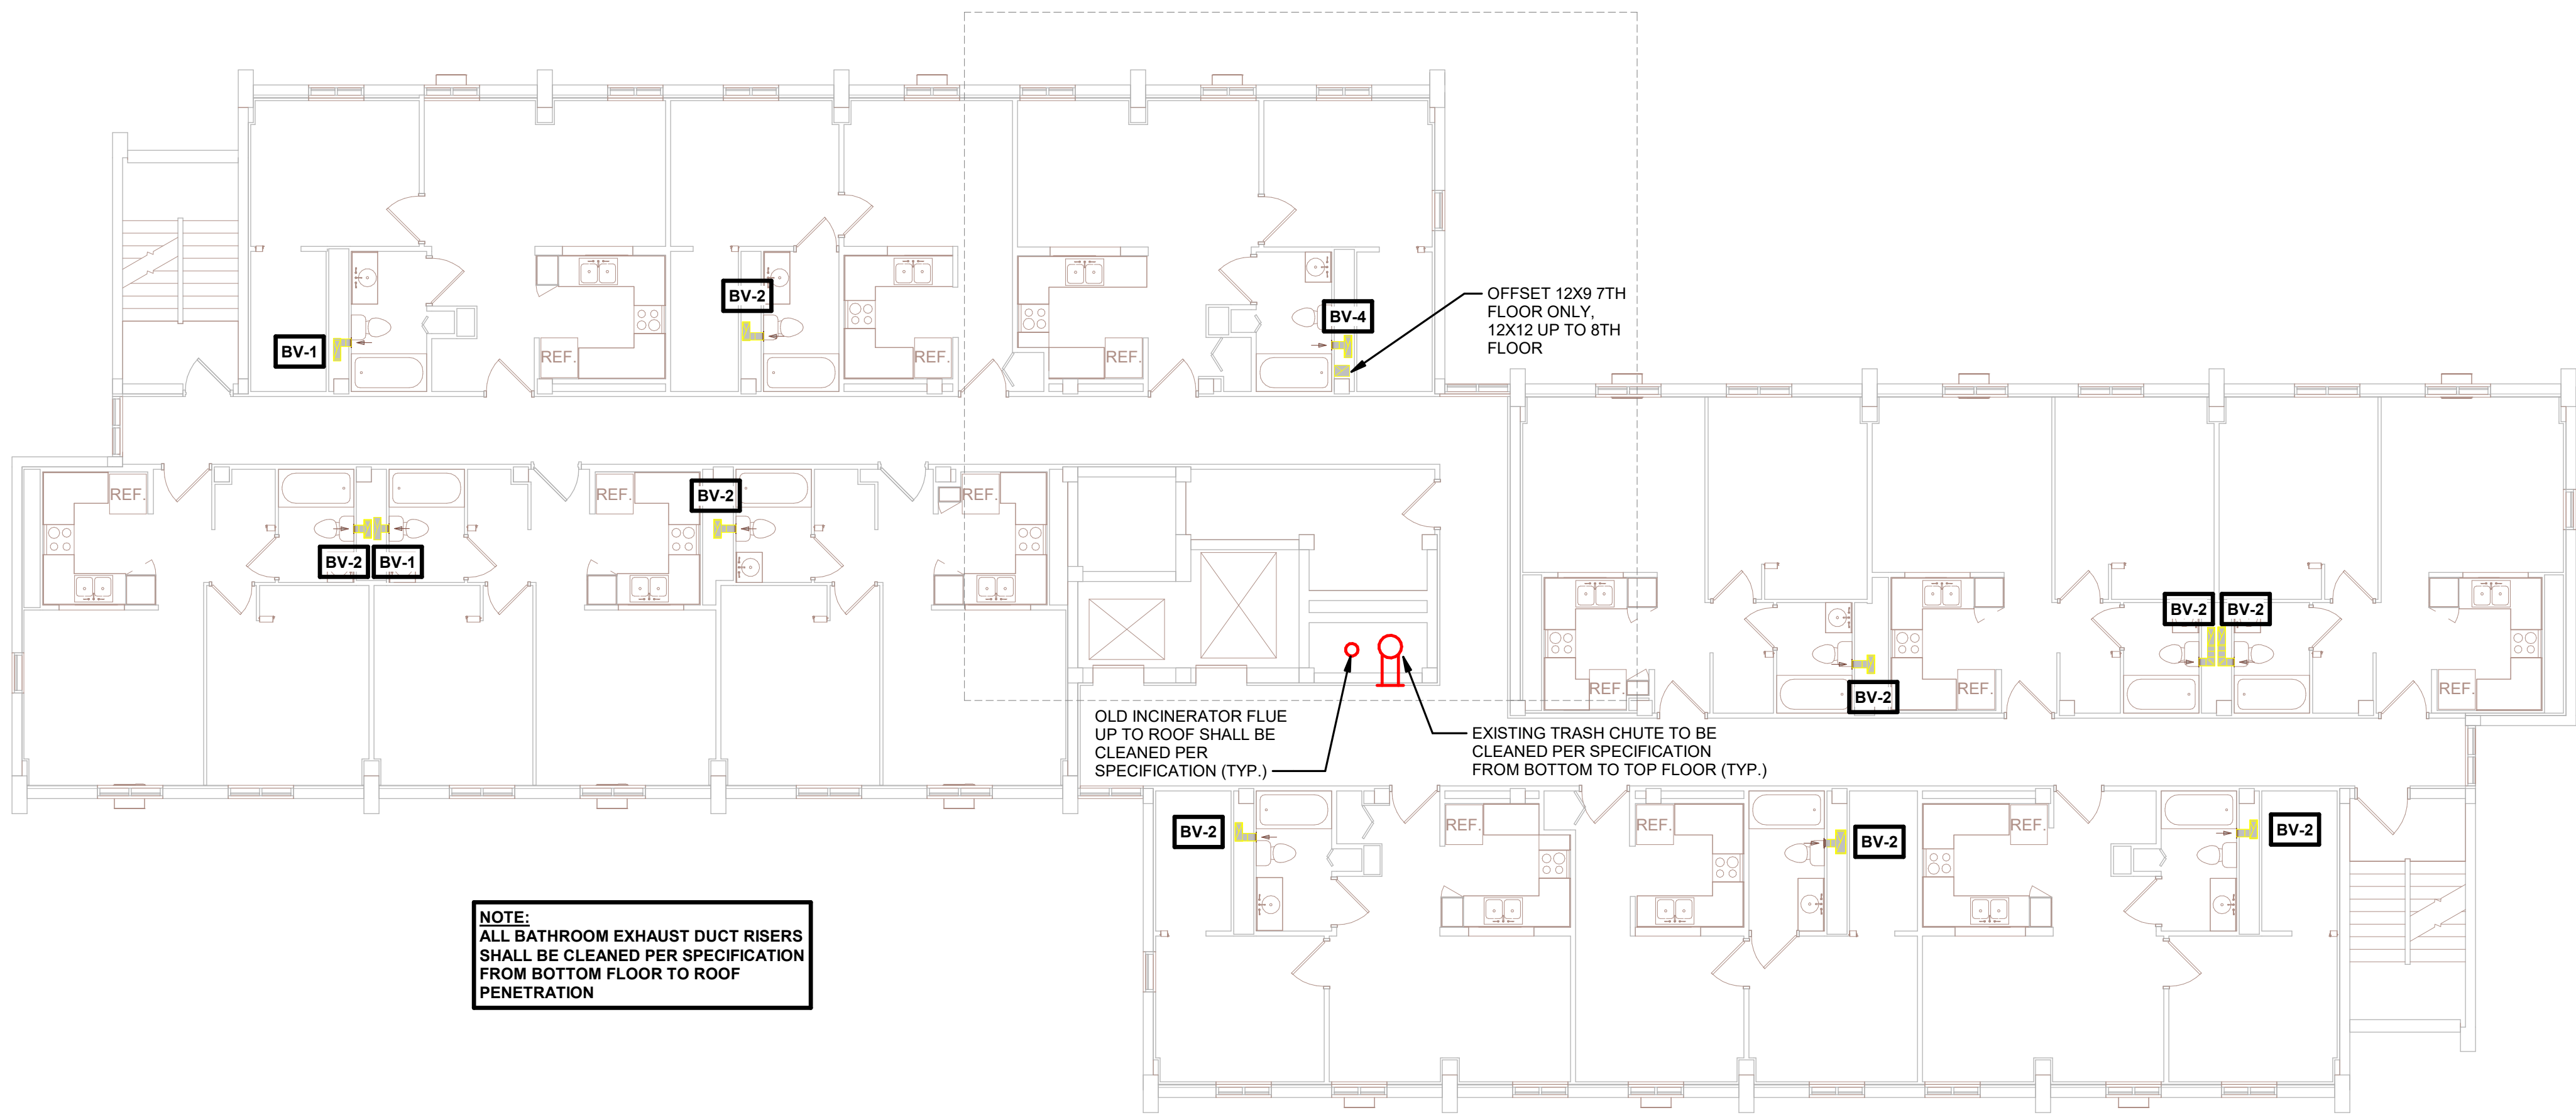


2 2ND THROUGH 8TH FLOOR HVAC

1/8" = 1'-0"

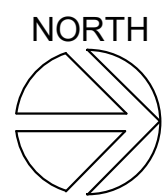

3 PARTIAL 8TH FLOOR HVAC

1/8" = 1'-0"

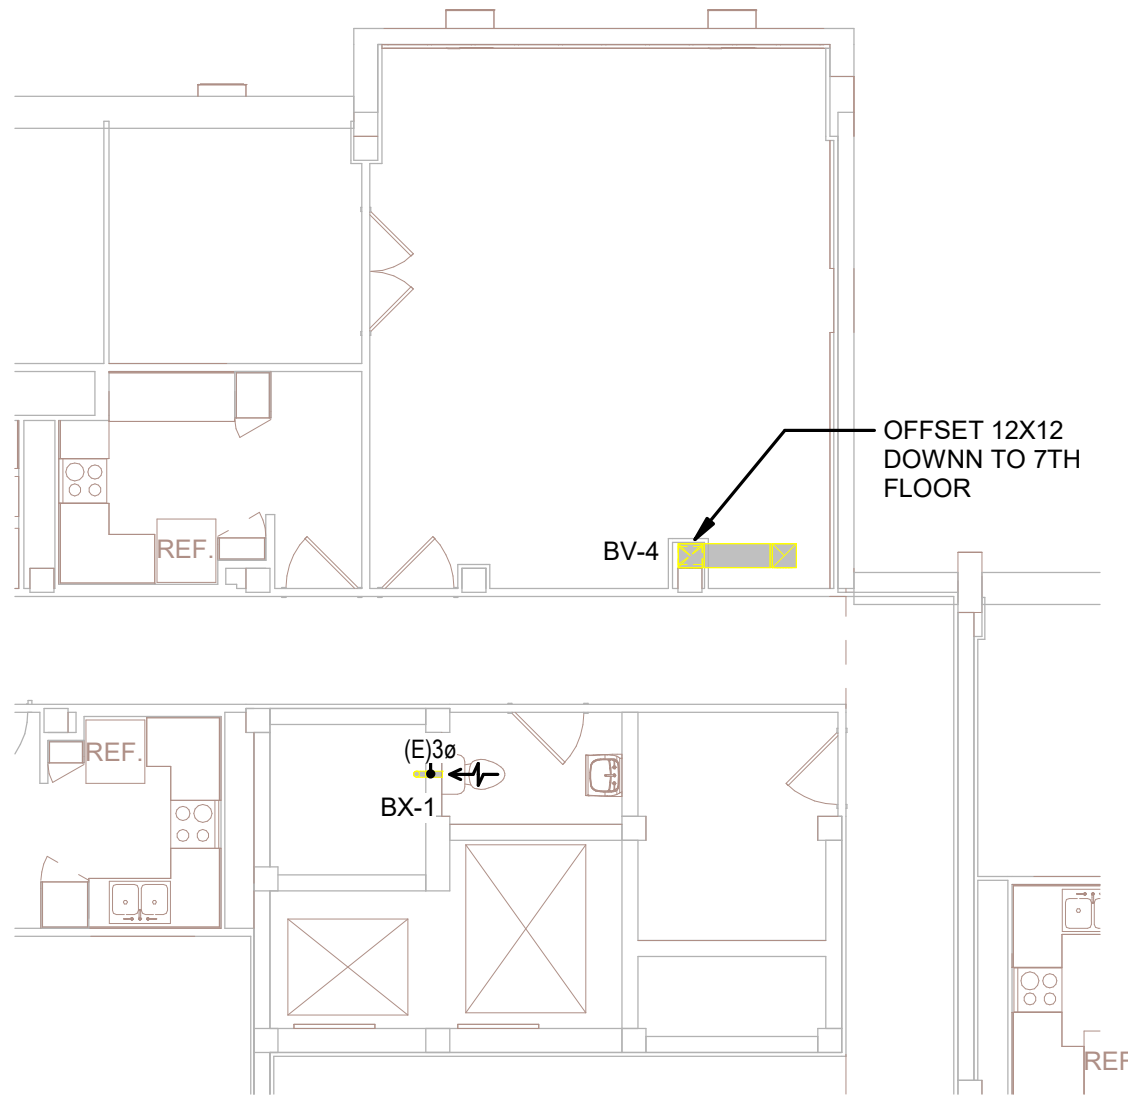

SAUBER MANOR

KEYNOTES - REMODEL	
Keynote Number	Keynote Description
1	ELECTRICAL CONTRACTOR TO DISCONNECT UNIT AND RE-CONNECT TO EXISTING ELECTRICAL CIRCUIT BACK TO SOURCE. TYPICAL THOUGHTOUT PROJECT.

ARCHITECTURE
ENGINEERING
INTERIOR DESIGN



HSR ASSOCIATES INC.
100 MILWAUKEE STREET
LA CROSSE, WISCONSIN
PHONE: 608.784.1830
FAX: 608.782.5844
www.hsrassociates.com

Consultant:

HOUSING AUTHORITY OF THE CITY OF LA CROSSE
2026 CAPITAL IMPROVEMENTS PROJECTS

1307 BADGER STREET
LA CROSSE, WI 54602

FLOOR PLANS, DETAILS, AND SCHEDULES


Project Title:	HSR Project Number:
Project Date:	26039
Drawn By:	SEPT 24, 2026
Key Plan:	JB/AB

Revisions:		
No.	Description	Date

BID SET


Graphic Scale:
0 2 4 6 8 10 12

MEP211

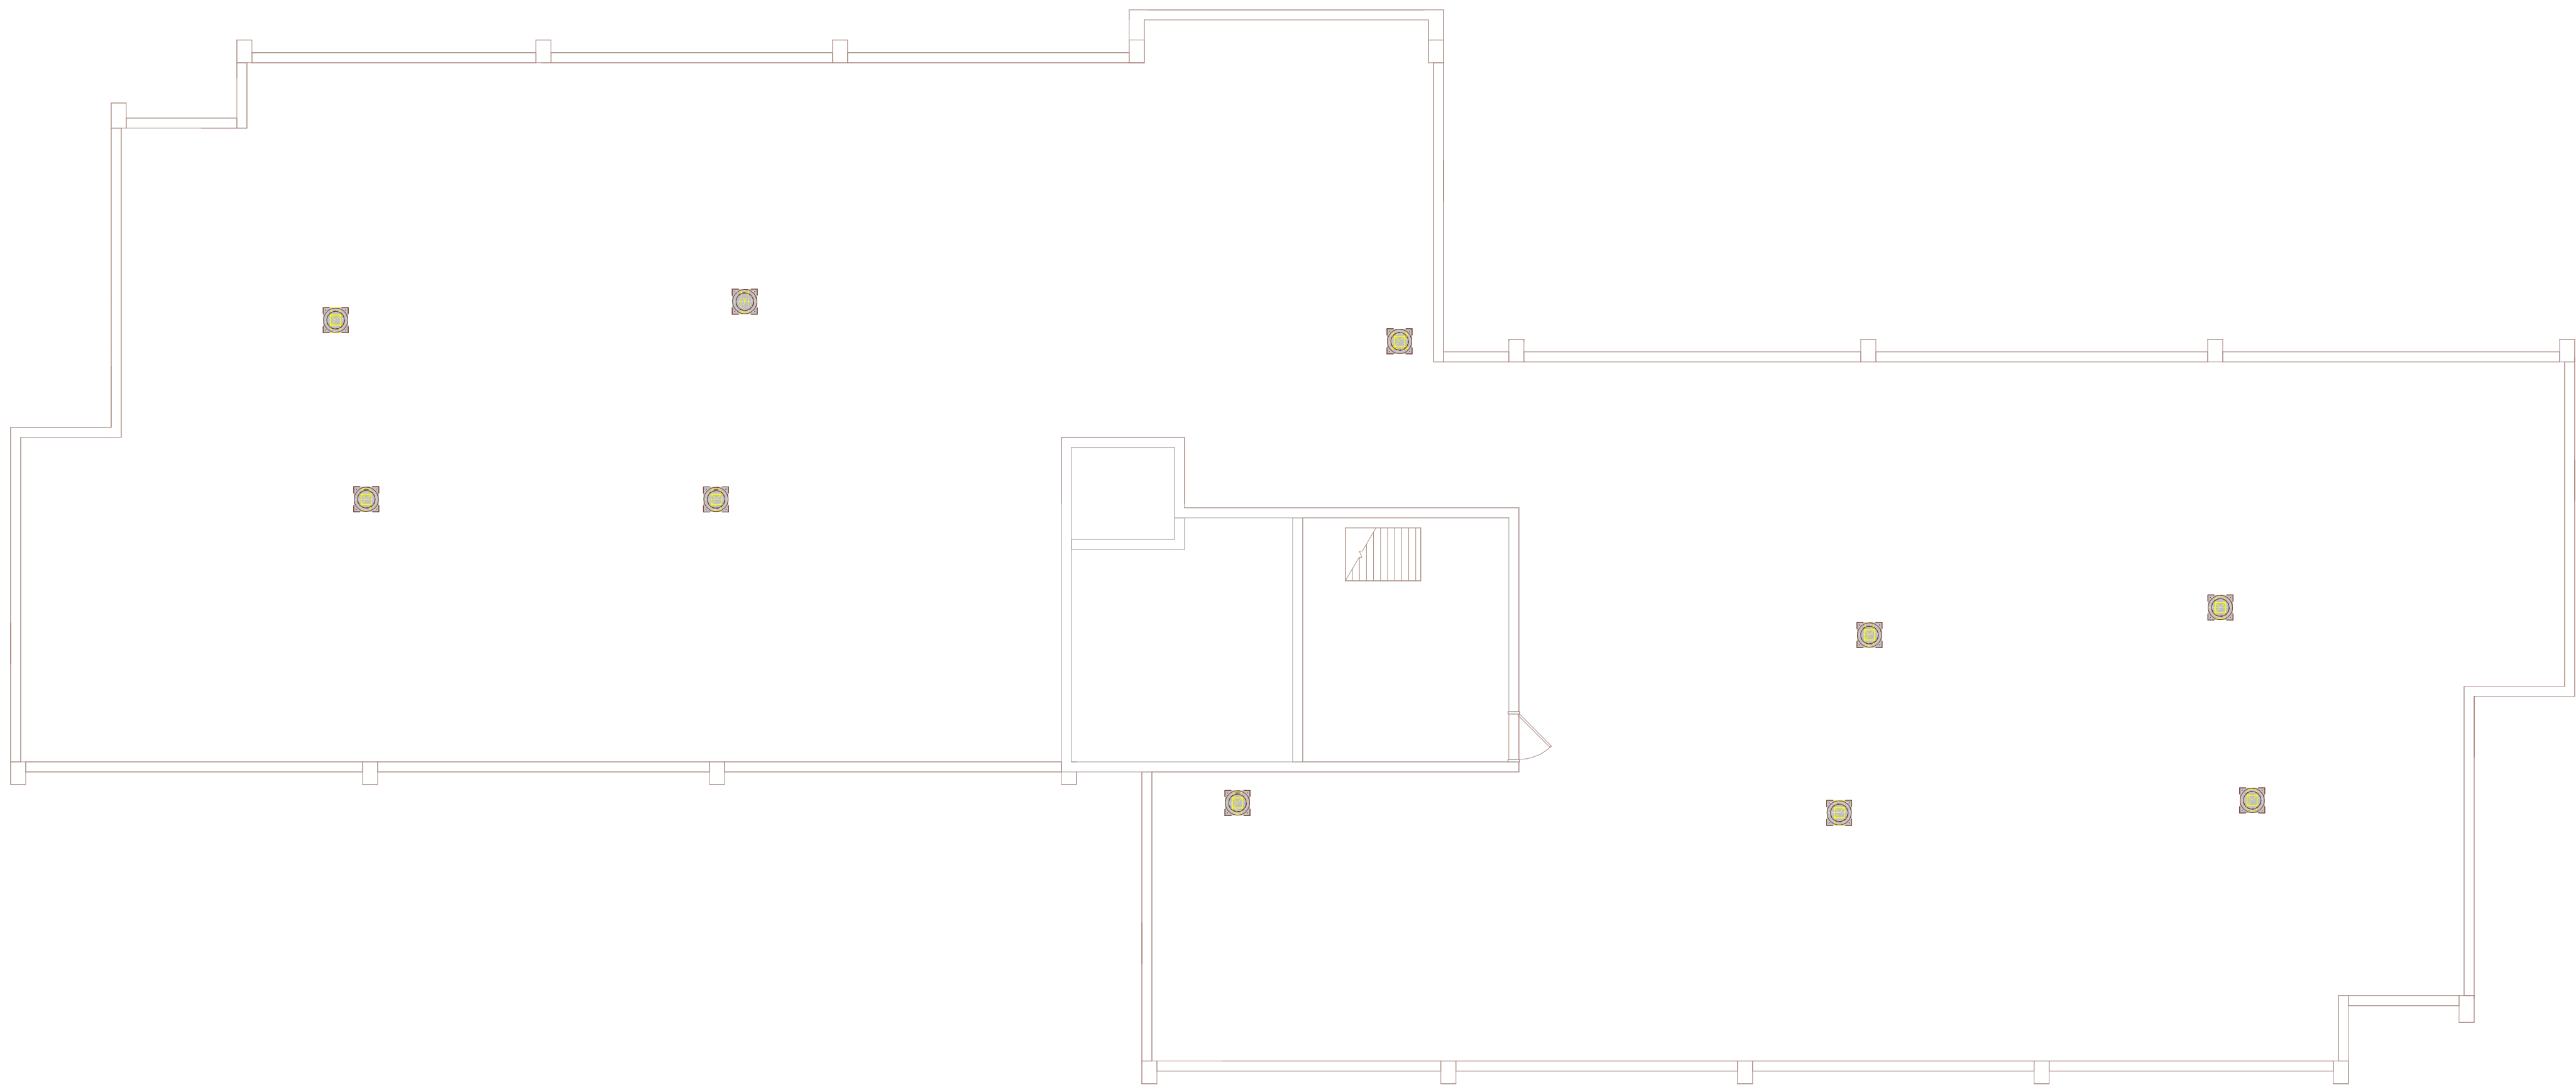

NORTH
1 ROOF HVAC
1/8" = 1'-0"

SCHEDULE OF DUCT RISERS										
DUCT RISER	BV-1		BV-2		BV-3		BV-4		MAIN SUPPLY RISER	
GRILLE ON	DUCT SIZE (INSIDE FREE AREA)	CFM	DUCT SIZE (INSIDE FREE AREA)	CFM	DUCT SIZE (INSIDE FREE AREA)	CFM	DUCT SIZE (INSIDE FREE AREA)	CFM	DUCT SIZE (INSIDE FREE AREA)	DEFLECTOR SIZE
1ST FLOOR	6 X 4	75	-	-	8 X 10	400	6 X 4	75	24 X 16	1750
2ND FLOOR	6 X 7	150	6 X 4	75	8 X 12	475	6 X 7	150	30 X 16	3100
3RD FLOOR	6 X 9	225	6 X 7	150	8 X 13	550	6 X 9	225	30 X 20	4250
4TH FLOOR	6 X 11	300	6 X 9	225	8 X 15	625	6 X 11	300	30 X 22	5400
5TH FLOOR	6 X 13	375	6 X 11	300	8 X 16	700	6 X 13	375	34 X 24	6550
6TH FLOOR	6 X 15	450	6 X 13	375	8 X 17	775	6 X 15	450	40 X 24	7700
7TH FLOOR	6 X 18	525	6 X 15	450	8 X 19	850	6 X 18	525	44 X 24	8850
8TH FLOOR	6 X 20	600	6 X 18	525	8 X 20	925			48 X 24	10,000
QUANTITY	2		10		1		1			
SEE DETAIL	●		●		●		●			
REMARKS										

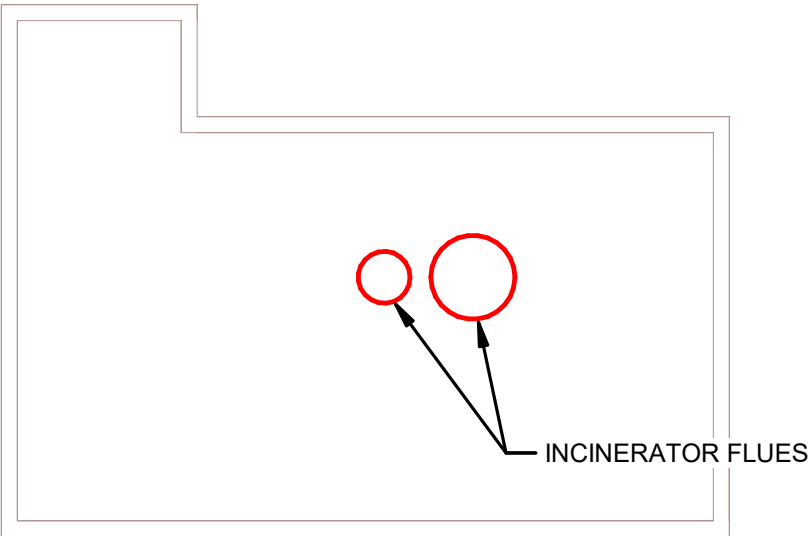

NORTH
2 PENTHOUSE HVAC
1/8" = 1'-0"

