
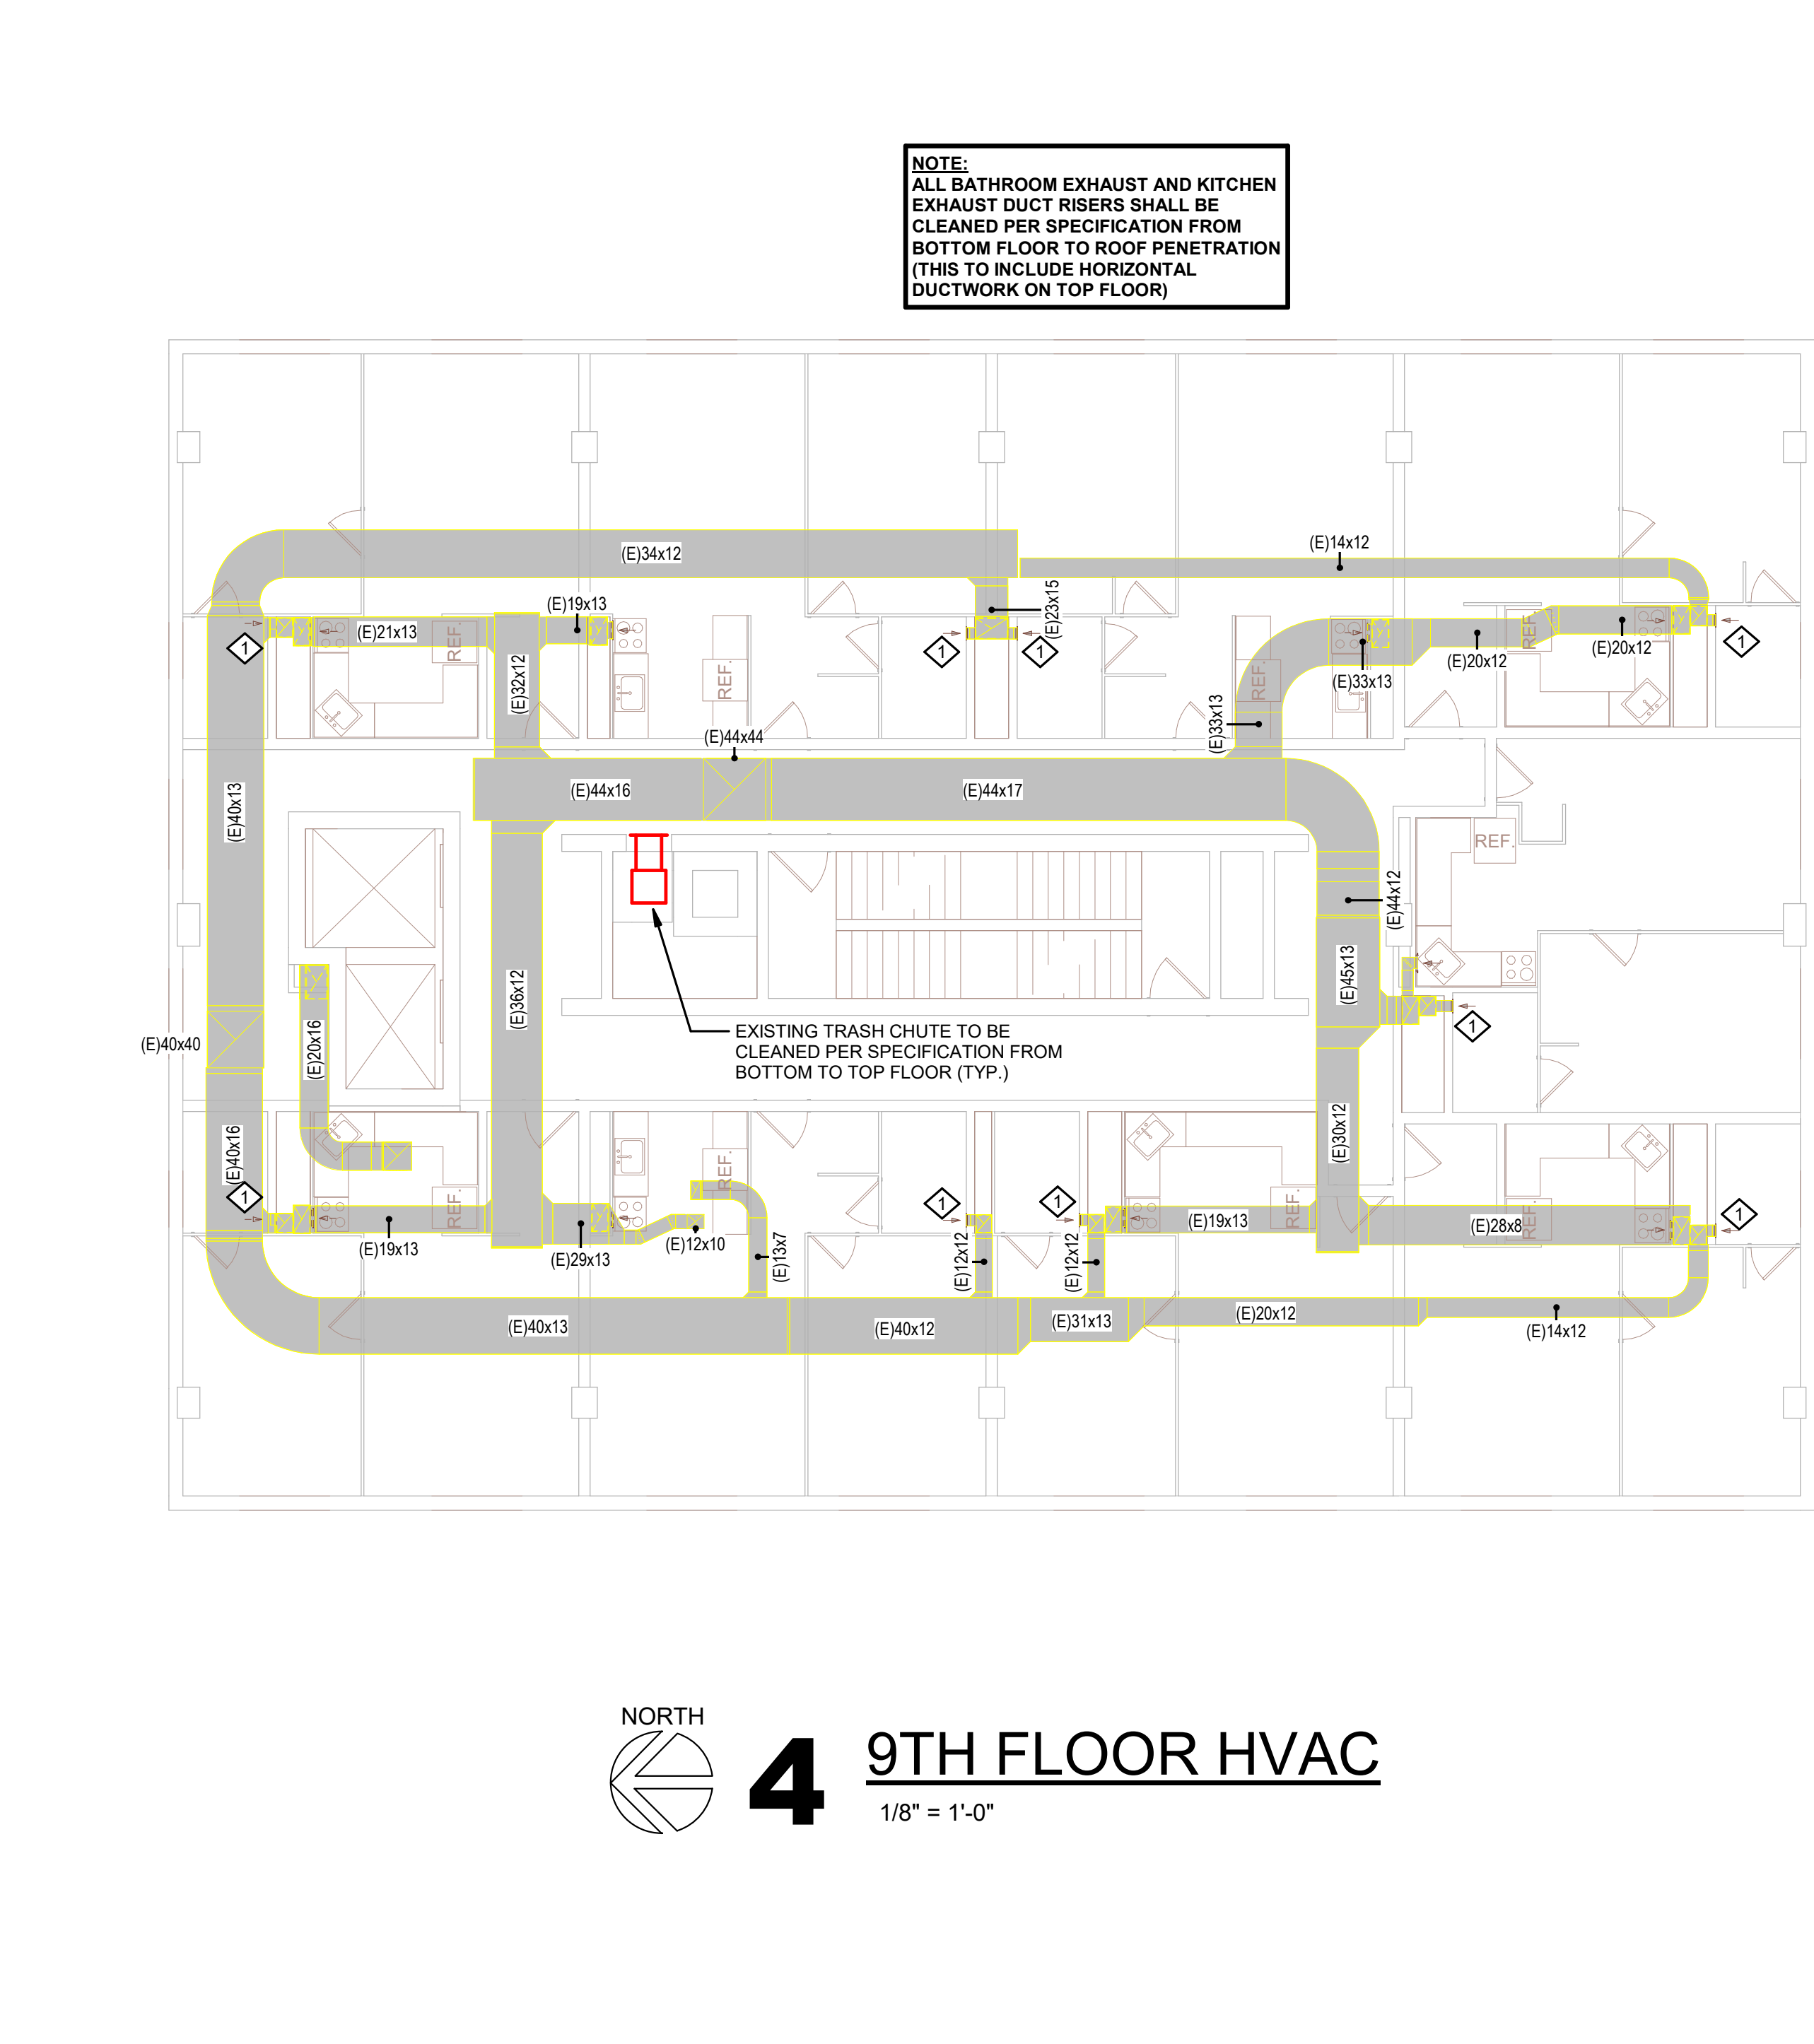
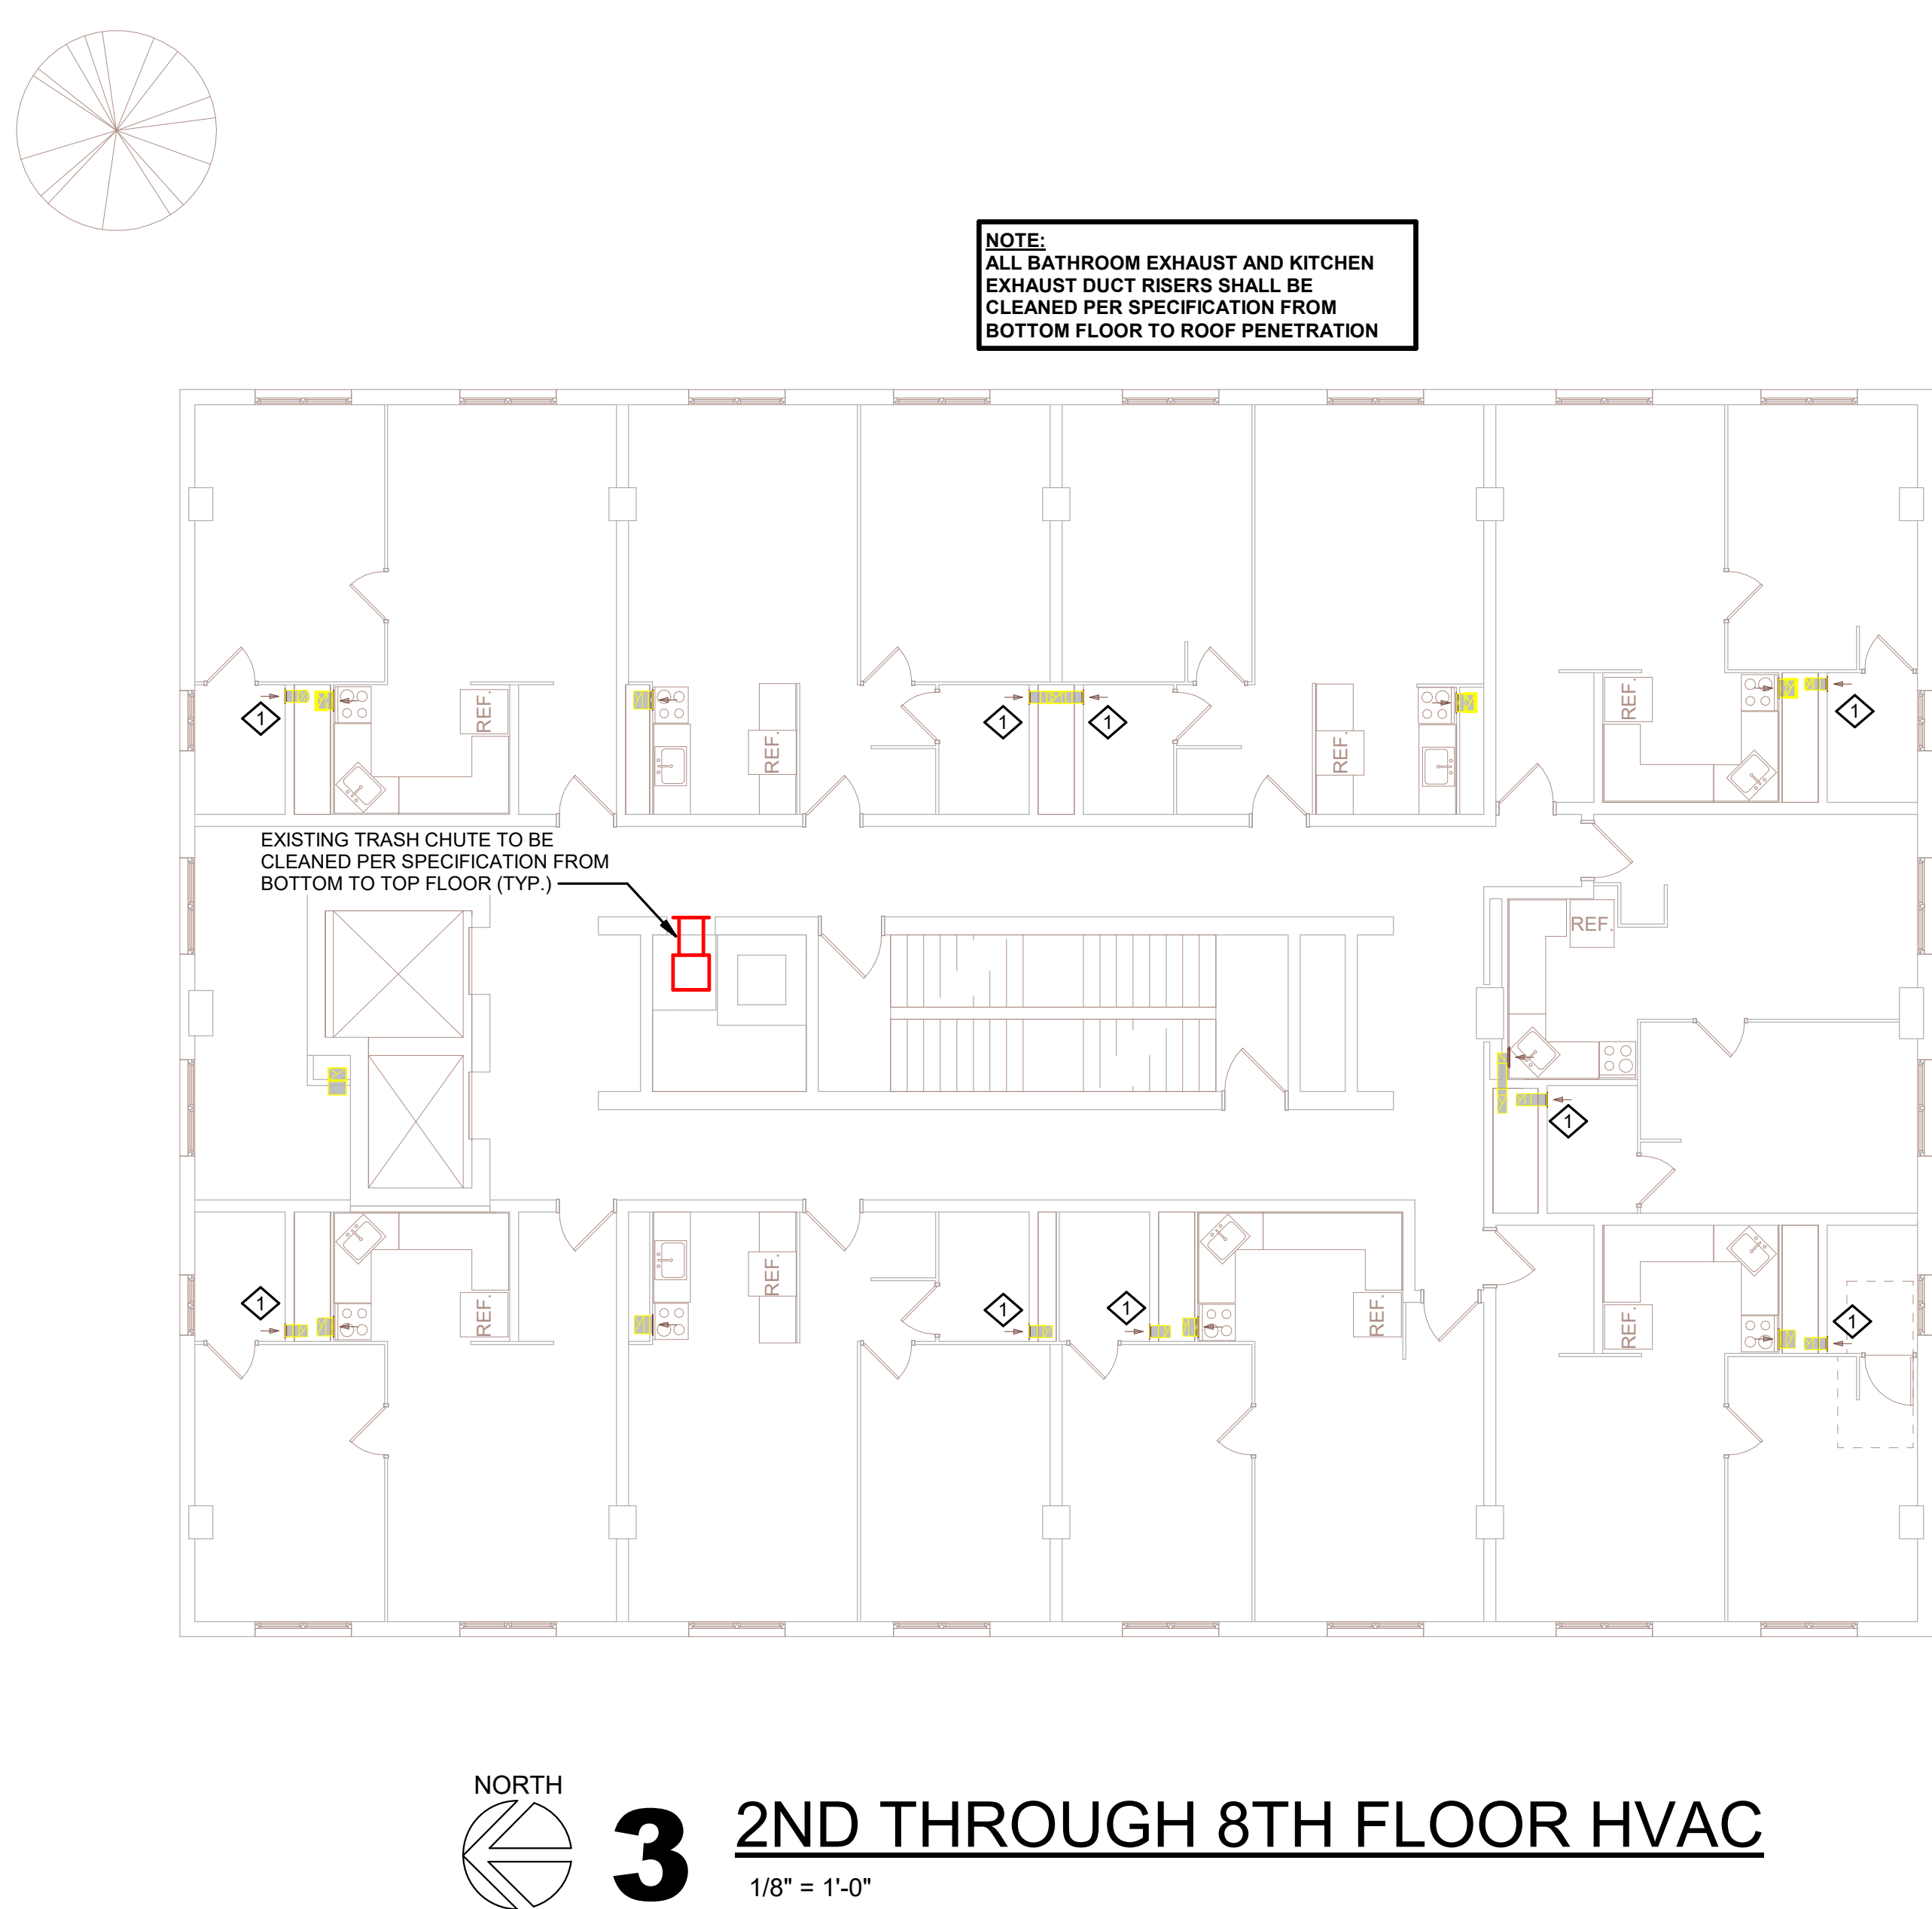
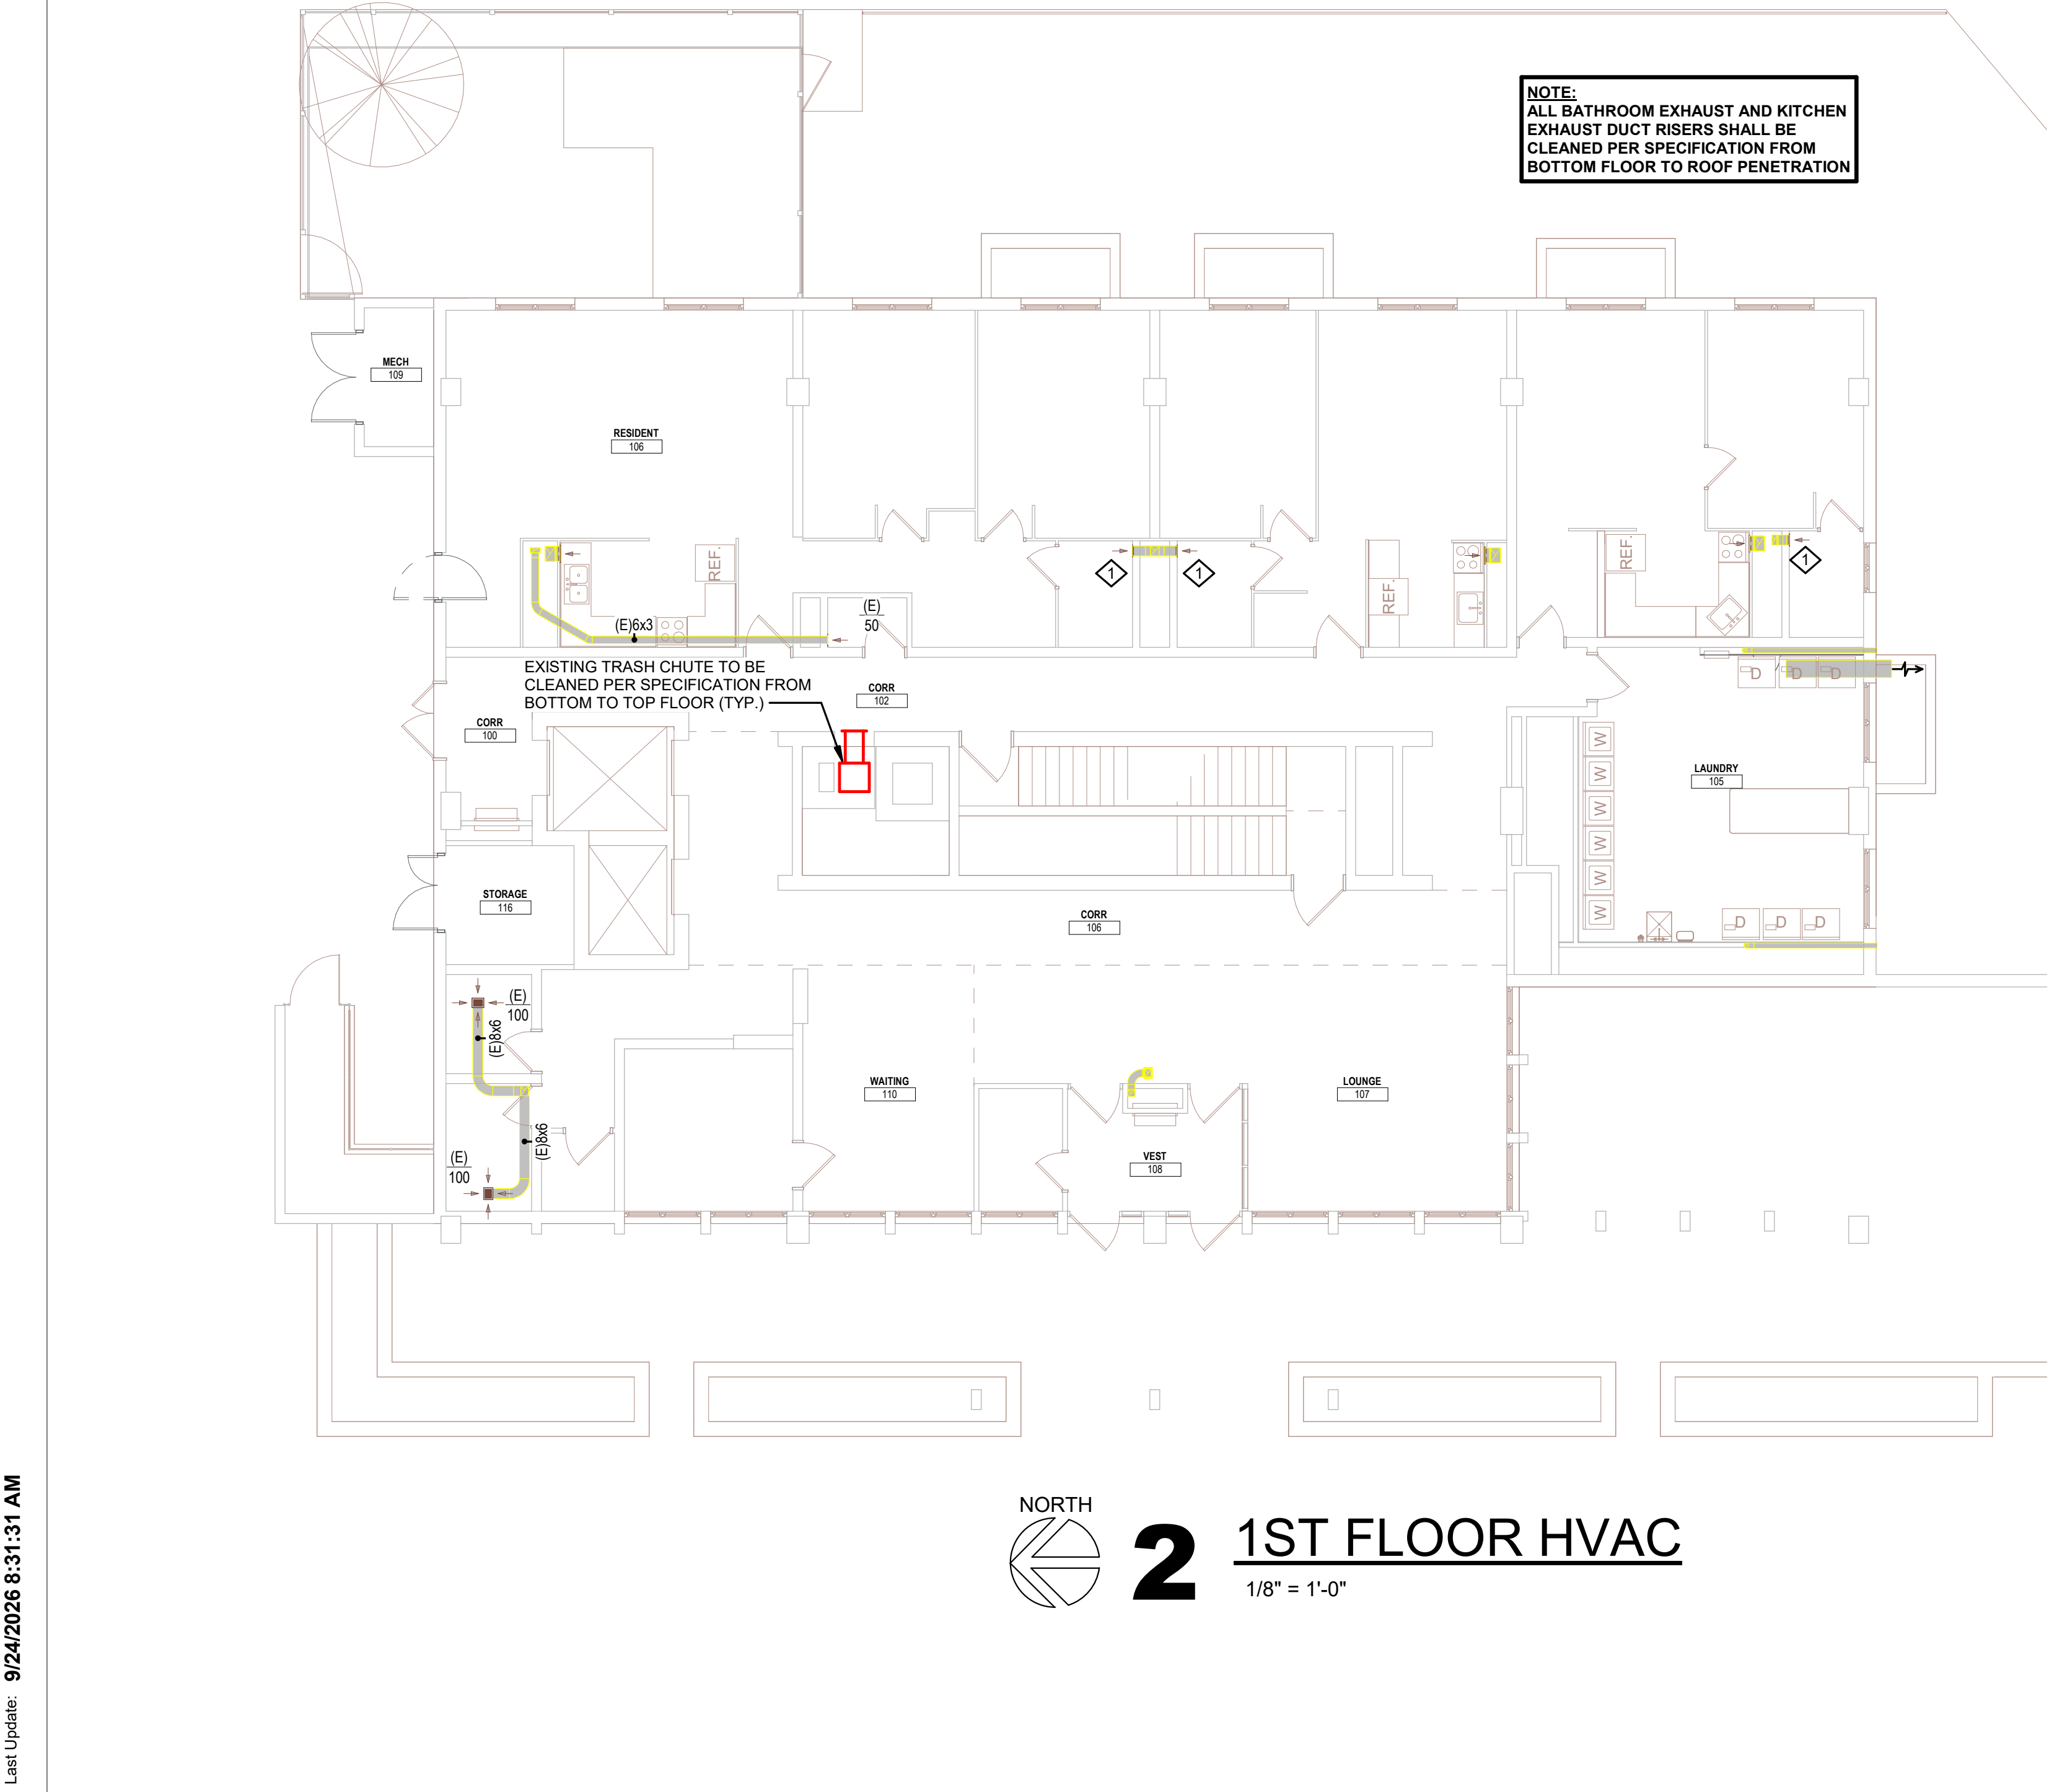


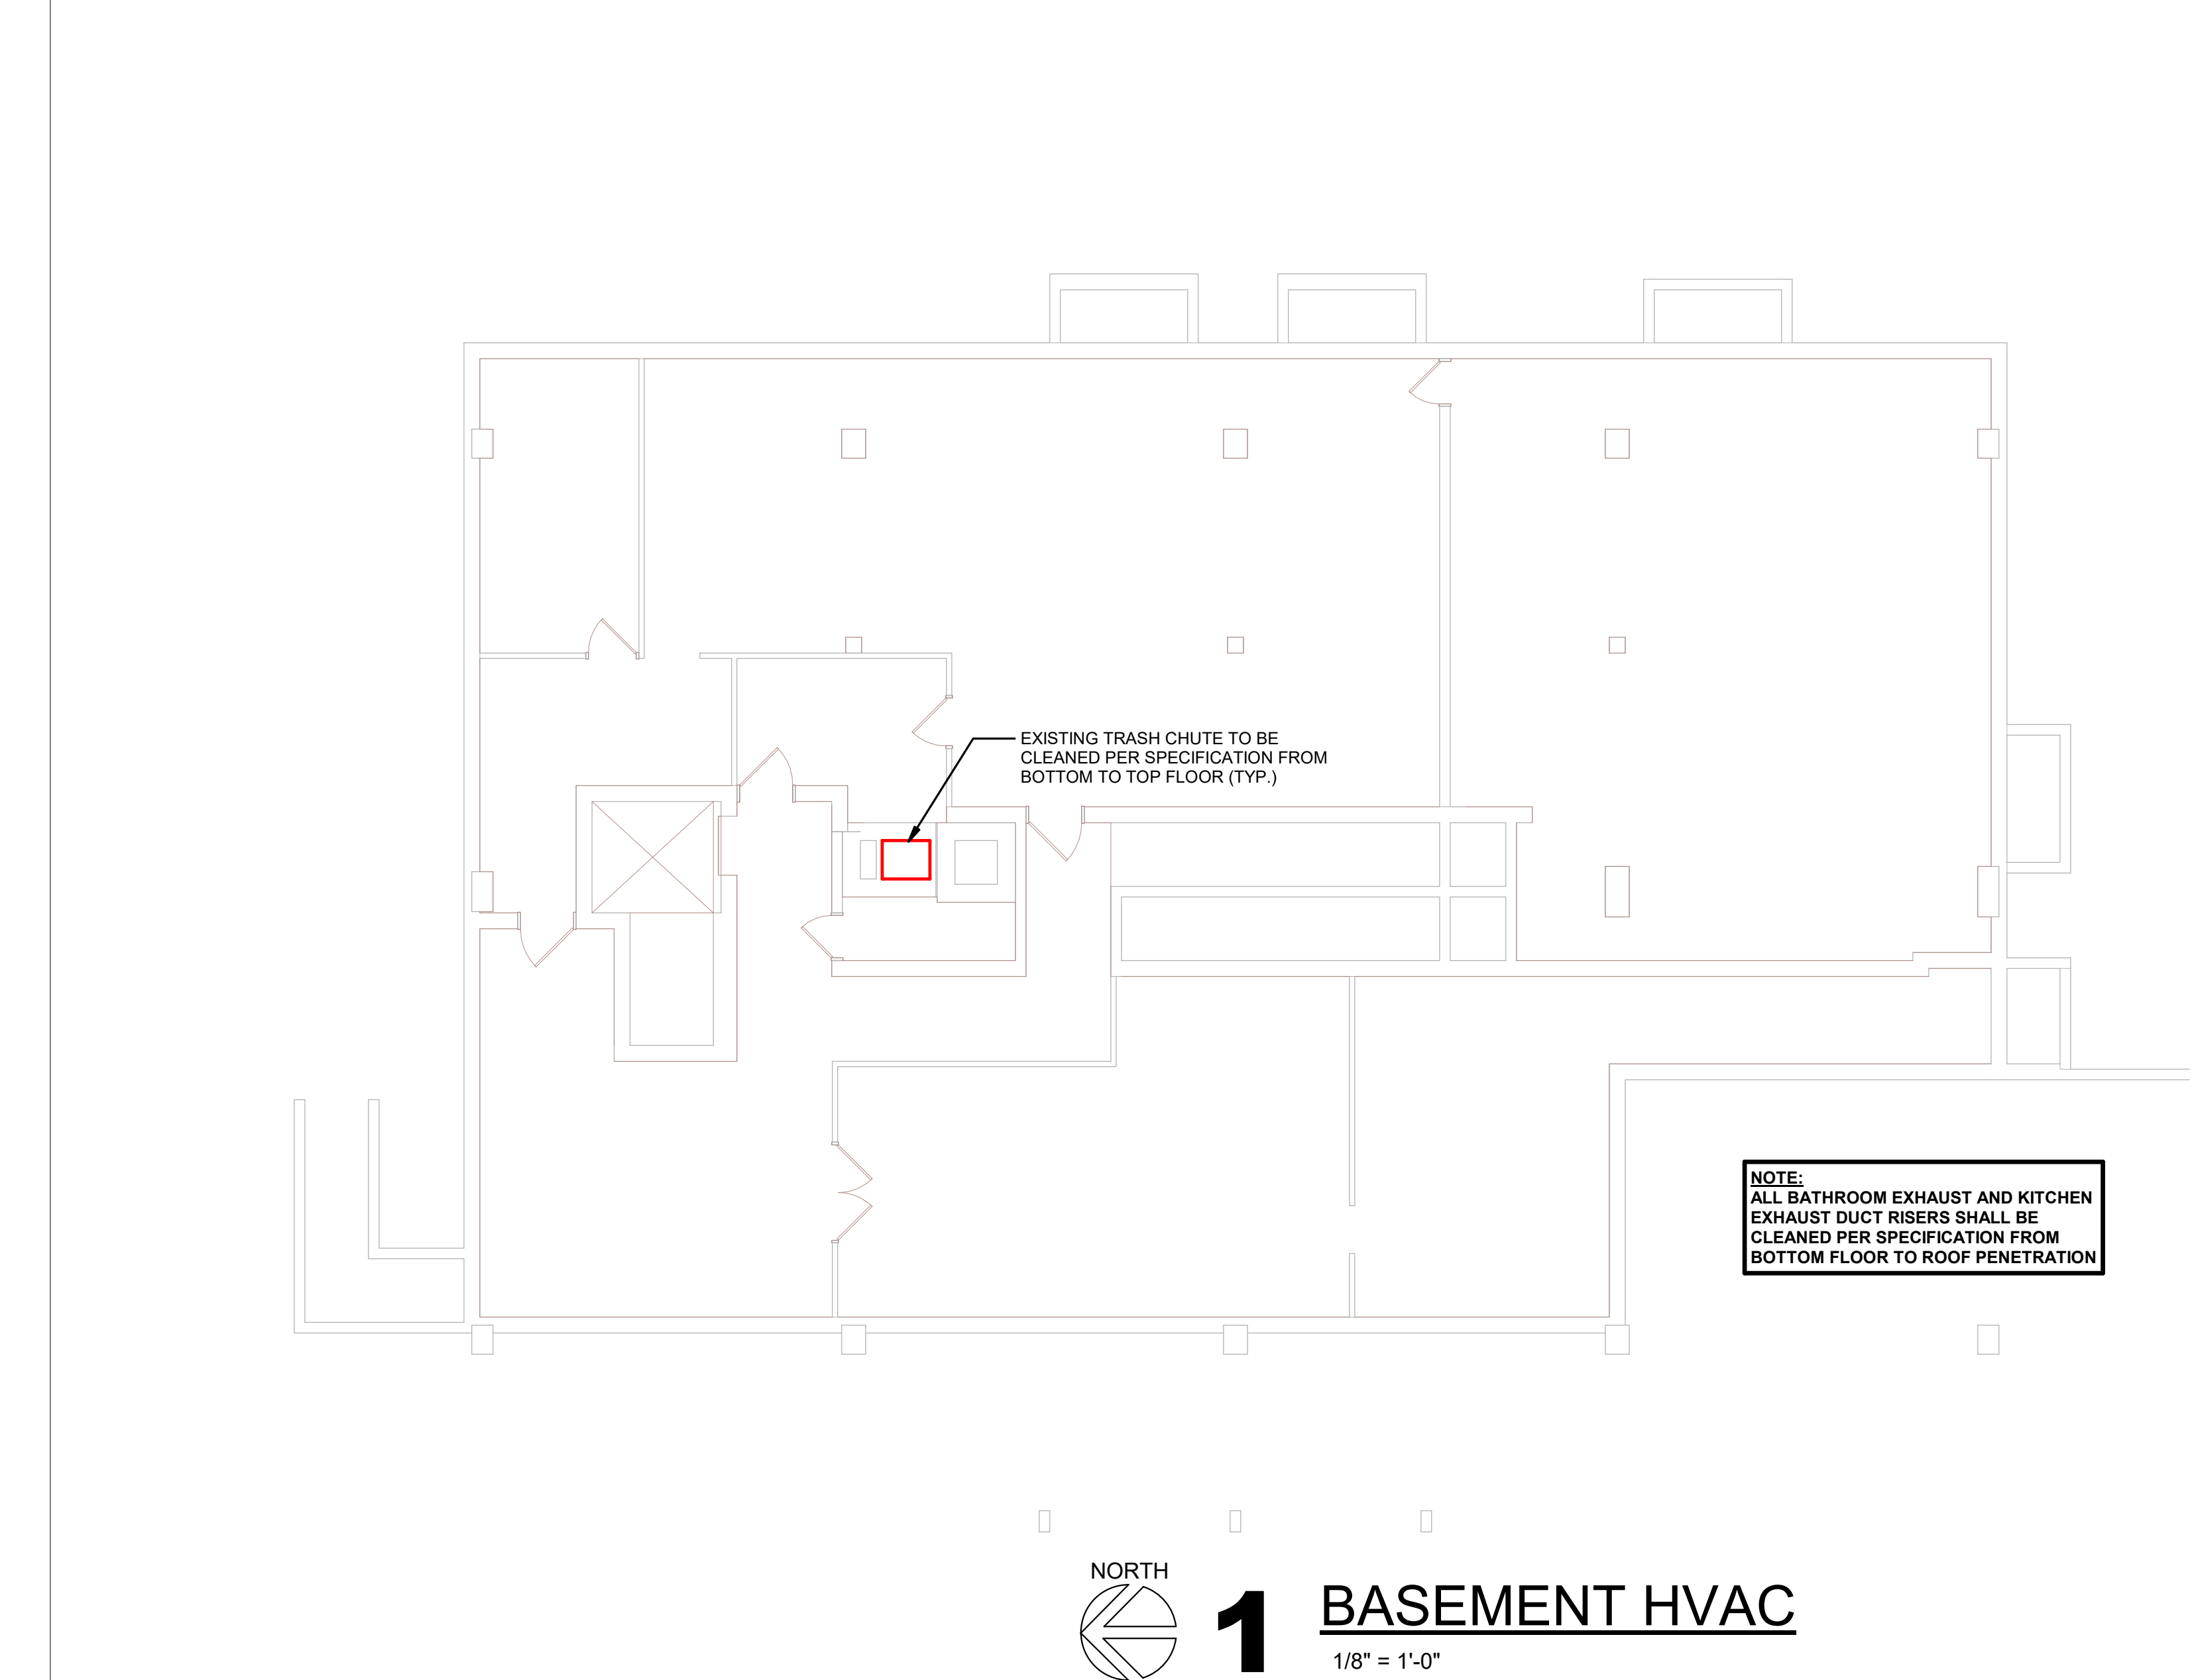

KEYNOTES - REMODEL	
Keynote Number	Keynote Description
#	COORDINATE EXACT LOCATION OF ALL CEILING MOUNTED GRILLES AND DIFFUSERS WITH CEILING GRID, SPRINKLER HEADS, RECESSED LIGHTING AND ALL OTHER CEILING MOUNTED EQUIPMENT.
1	EXISTING UNIT EXHAUST FAN TO BE REMOVED ALONG WITH ANY VOLUME DAMPERS WITHIN DUCTWORK. PROVIDE NEW BLADE STYLE EXHAUST GRILLE (WHITE ALUMINUM) TO COVER EXISTING OPENING (MECHANICAL CONTRACTOR TO FIELD VERIFY EXISTING SIZES PRIOR TO ORDER). PROVIDE NEW AUTOMATIC BALANCING DAMPER (GREENWICK ASD-1) IN BRANCH EXHAUST DUCTWORK, SET TO 100 CFM. PATCH WALL AROUND EXHAUST GRILLE AND PAINT TO MATCH EXISTING. ELECTRICAL CONTRACTOR TO DISCONNECT UNIT AND REMOVE EXISTING ELECTRICAL CIRCUIT BACK TO SOURCE. TYPICAL THOUGHTOUT PROJECT.
2	ELECTRICAL CONTRACTOR TO RE-CONNECT CIRCUIT TO NEW UNIT. COORDINATE WITH MECHANICAL CONTRACTOR. VAV FEEDER VARY (3) #14 CONDUCTORS (1) #14 NEUTRAL (1) #14 GROUND 3/4" EMT CONDUIT, RX-1 FEEDER VARY (3) #8 CONDUCTORS (1) #8 NEUTRAL (1) #10 GROUND 3/4" EMT CONDUIT.

ARCHITECTURE
ENGINEERING
INTERIOR DESIGN

HSR ASSOCIATES INC.
100 MILWAUKEE STREET
LA CROSSE, WISCONSIN
PHONE: 608.784.1830
FAX: 608.782.5844
www.hsrassociates.com

Consultant:

HOUSING AUTHORITY OF THE CITY OF LA CROSSE
2026 CAPITAL IMPROVEMENTS PROJECTS

Project Title: 26039
Project Date: SEPT 24, 2026
Drawn By: JB/AB
Key Plan:

Project Location: 1307 BADGER STREET
LA CROSSE, WI 54602

Sheet Title: FLOOR PLANS

BID SET

Revisions:

No.	Description	Date

Graphic Scale:
0 2 4 6 12

MEP410

STOFFEL COURT

ROOF EXHAUSTER SCHEDULE																													
UNIT NO.	MANUFACTURER	MODEL NO.	SERVES	EXHAUST FAN							EXHAUST AIR CONNECTOR		ROOF/WALL OPENING		ELECTRICAL				REFERENCE		REMARKS:								
				AIRFLOW	TYPE	EXT. STATIC PRESS.	FAN BRAKE POWER	FAN RPM	MAX FAN RPM	DRIVE TYPE	QTY	POWER	DUCT WIDTH	DUCT HEIGHT	LENGTH	WIDTH	UNIT WEIGHT	SONES	MCA	MOP	VOLTAGE	PHASE	DETAIL NO.	CONTROL	1. PROVIDE INSULATED 24" ATI SOUND ATTENUATING ROOF CURB. 2. PROVIDE CURB SEALS & BIRDSCREEN. 3. PROVIDE FACTORY ELECTRICAL DISCONNECT WITHIN UNIT HOUSING. 4. PROVIDE FACTORY MOUNTED DIAL SPEED CONTROLLER. 5. PROVIDE FACTORY VFD, RATED MOTOR W/ SHAFT GROUNDING. 6. PROVIDE ROOF CURB ADAPTER FOR EXISTING ROOF CURB (FIELD VERIFY SIZES). 7. PROVIDE GRAVITY BACKDRAFT DAMPER. 8. PROVIDE NEW TIMECLOCK WITH FAN FOR ON/OFF BUILDING CONTROL. LOCATE WITHIN PENTHOUSE. 9. PROVIDE FULL FAN EXHAUST SYSTEM AIR BALANCING.				
RX-1	GREENHECK	GB-300-50	BATHROOM EXHAUST	8150 CFM	DOWNBLAST	1.50 in-wg	3.72 hp	815	891	BELT	1	5.00 hp	34"	34"	36 1/2"	36 1/2"	271 lbf	18.2	21 A	40 A	208 V	3		TIMECLOCK	1,2,3,4,5,6,7,8,9				
Grand total: 1																													

VARIABLE FREQUENCY DRIVE SCHEDULE										REMARKS:	
UNIT NO.	EQUIPMENT SERVED	MANUFACTURER	INPUT DISCONNECT	INTEGRAL BYPASS	MOTOR BHP	MOTOR HP	ELECTRICAL VOLTAGE	PHASE			
VFD-RX-1	RX-1	ABB, Inc.	YES	NO	3.72 hp	5.00 hp	208 V	3		PROVIDE BY MECHANICAL & INSTALLED BY ELECTRICAL	

KEYNOTES - REMODEL	
Keynote Number	Keynote Description
1	EXISTING UNIT EXHAUST FAN TO BE REMOVED ALONG WITH ANY VOLUME DAMPERS WITHIN DUCTWORK. PROVIDE NEW BLADE STYLE EXHAUST GRILLE (WHITE, ALUMINUM) TO COVER EXISTING OPENINGS (MECHANICAL CONTRACTOR TO FIELD VERIFY EXISTING SIZES PRIOR TO ORDER). PROVIDE NEW AUTOMATIC BALANCING DAMPER (GREENHECK ADD-T) IN BRANCH EXHAUST DUCTWORK. SET TO 100 CFM. PATCH WALL AROUND EXHAUST GRILLE AND PAINT TO MATCH EXISTING. ELECTRICAL CONTRACTOR TO DISCONNECT UNIT AND REMOVE EXISTING ELECTRICAL CIRCUIT BACK TO SOURCE. TYPICAL THOUGHTOUT PROJECT.
2	ELECTRICAL CONTRACTOR TO RE-CONNECT CIRCUIT TO NEW UNIT. COORDINATE WITH MECHANICAL CONTRACTOR. VAV FEEDER VARY (3) #14 CONDUCTORS (1) #14 NEUTRAL (1) #14 GROUND 3/4" EMT CONDUIT. RX-1 FEEDER VARY (3) #8 CONDUCTORS (1) #8 NEUTRAL (1) #10 GROUND 3/4" EMT CONDUIT.

ARCHITECTURE
ENGINEERING
INTERIOR DESIGN



HSR ASSOCIATES INC.
100 MILWAUKEE STREET
LA CROSSE, WISCONSIN
PHONE: 608.784.1830
FAX: 608.782.5844
www.hsrassociates.com

Consultant:

HOUSING AUTHORITY OF THE CITY OF LA CROSSE
2026 CAPITAL IMPROVEMENTS PROJECTS

1307 BADGER STREET
LA CROSSE, WI 54602

FLOOR PLANS, DETAILS, AND SCHEUDLES

Project Title: HOUSING AUTHORITY OF THE CITY OF LA CROSSE
2026 CAPITAL IMPROVEMENTS PROJECTS

Project Number: 26039

Project Date: SEPT 24, 2026

Drawn By: JB/AB

Key Plan:

BID SET

Revisions:	No.	Description	Date

Graphic Scale: 0 2 4 6 8 12

MEP411

STOFFEL COURT

