

Project Location: **1307 BADGER STREET
LA CROSSE, WI 54602**

Project Location: **1307 BADGER STREET**

Sheet Title:

FLOOR PLANS

26039

SEPT 24, 2026

JB/AB

Graphic Scale:



0' 2' 4' 8' 12'

--	--


$$1/8'' = 1'-0''$$

NOTE:
ALL BATHROOM EXHAUST AND KITCHEN
EXHAUST DUCT RISERS SHALL BE
CLEANED PER SPECIFICATION FROM
BOTTOM FLOOR TO ROOF PENETRATION

NOTE:
ALL BATHROOM EXHAUST AND KITCHEN
EXHAUST DUCT PENETRATIONS THRU
FLOOR CONTAIN FIRE DAMPERS

EXISTING TRASH CHUTE TO BE
CLEANED PER SPECIFICATION FROM
BOTTOM TO TOP FLOOR (TYPICAL) —


$$1/8'' = 1'-0''$$

NOTE:
ALL BATHROOM EXHAUST AND KITCHEN
EXHAUST DUCT RISERS SHALL BE
CLEANED PER SPECIFICATION FROM
BOTTOM FLOOR TO ROOF PENETRATION

NOTE:
ALL BATHROOM EXHAUST AND KITCHEN
EXHAUST DUCT PENETRATIONS THRU
FLOOR CONTAIN FIRE DAMPERS



HSR ASSOCIATES INC.
100 MILWAUKEE STREET
LA CROSSE, WISCONSIN
PHONE: 608.784.1830
FAX: 608.782.5844
www.hsrassociates.com

Consultant:

HOUSING AUTHORITY OF THE CITY OF LA CROSSE
2026 CAPITAL IMPROVEMENTS PROJECTS
Project Title:
Project Location: 1307 BADGER STREET
LA CROSSE, WI 54602
Sheet Title: FLOOR PLANS

HSR Project Number:
26039
Project Date:
SEPT 24, 2026
Drawn By:
JB/AB
Key Plan:

BID SET


Revisions:		
No.	Description	Date

Graphic Scale:
0 2 4 6 12

MEP611


FOREST PARK

KEYNOTES - REMODEL	
Keynote Number	Keynote Description
1	COORDINATE EXACT LOCATION OF ALL CEILING MOUNTED GRILLES AND DIFFUSERS WITH CEILING GRID. SPRINKLER HEADS, RECESSED LIGHTING AND ALL OTHER CEILING MOUNTED EQUIPMENT.
2	EXISTING UNIT EXHAUST FAN TO BE REMOVED ALONG WITH ANY VOLUME DAMPERS WITHIN DUCTWORK. PROVIDE NEW BLADE STYLE EXHAUST GRILLE (WHITE, ALUMINUM) TO COVER EXISTING OPENING (MECHANICAL CONTRACTOR TO FIELD VERIFY EXISTING SIZES PRIOR TO ORDER). PROVIDE NEW AUTOMATIC BALANCING DAMPER (GREENHECK ABD-T) IN BRANCH EXHAUST DUCTWORK. SET TO 60 CFM. PATCH WALL AROUND EXHAUST GRILLE AND PAINT TO MATCH EXISTING. ELECTRICAL CONTRACTOR TO DISCONNECT UNIT AND REMOVE EXISTING ELECTRICAL CIRCUIT BACK TO SOURCE. TYPICAL THOUGHTOUT PROJECT.
3	ELECTRICAL CONTRACTOR TO CONNECT NEW UNIT WITH ELECTRICAL CIRCUIT. PROVIDE 120V 20A CIRCUIT FROM NEAREST ELECTRICAL PANEL. FEEDER SIZE (2) #12 CONDUCTORS (1) #12 NEUTRAL (1) #12 GROUND 3/4" EMT CONDUIT. PROVIDE A TOGGLE SWITCH DISCONNECT FOR UNIT.

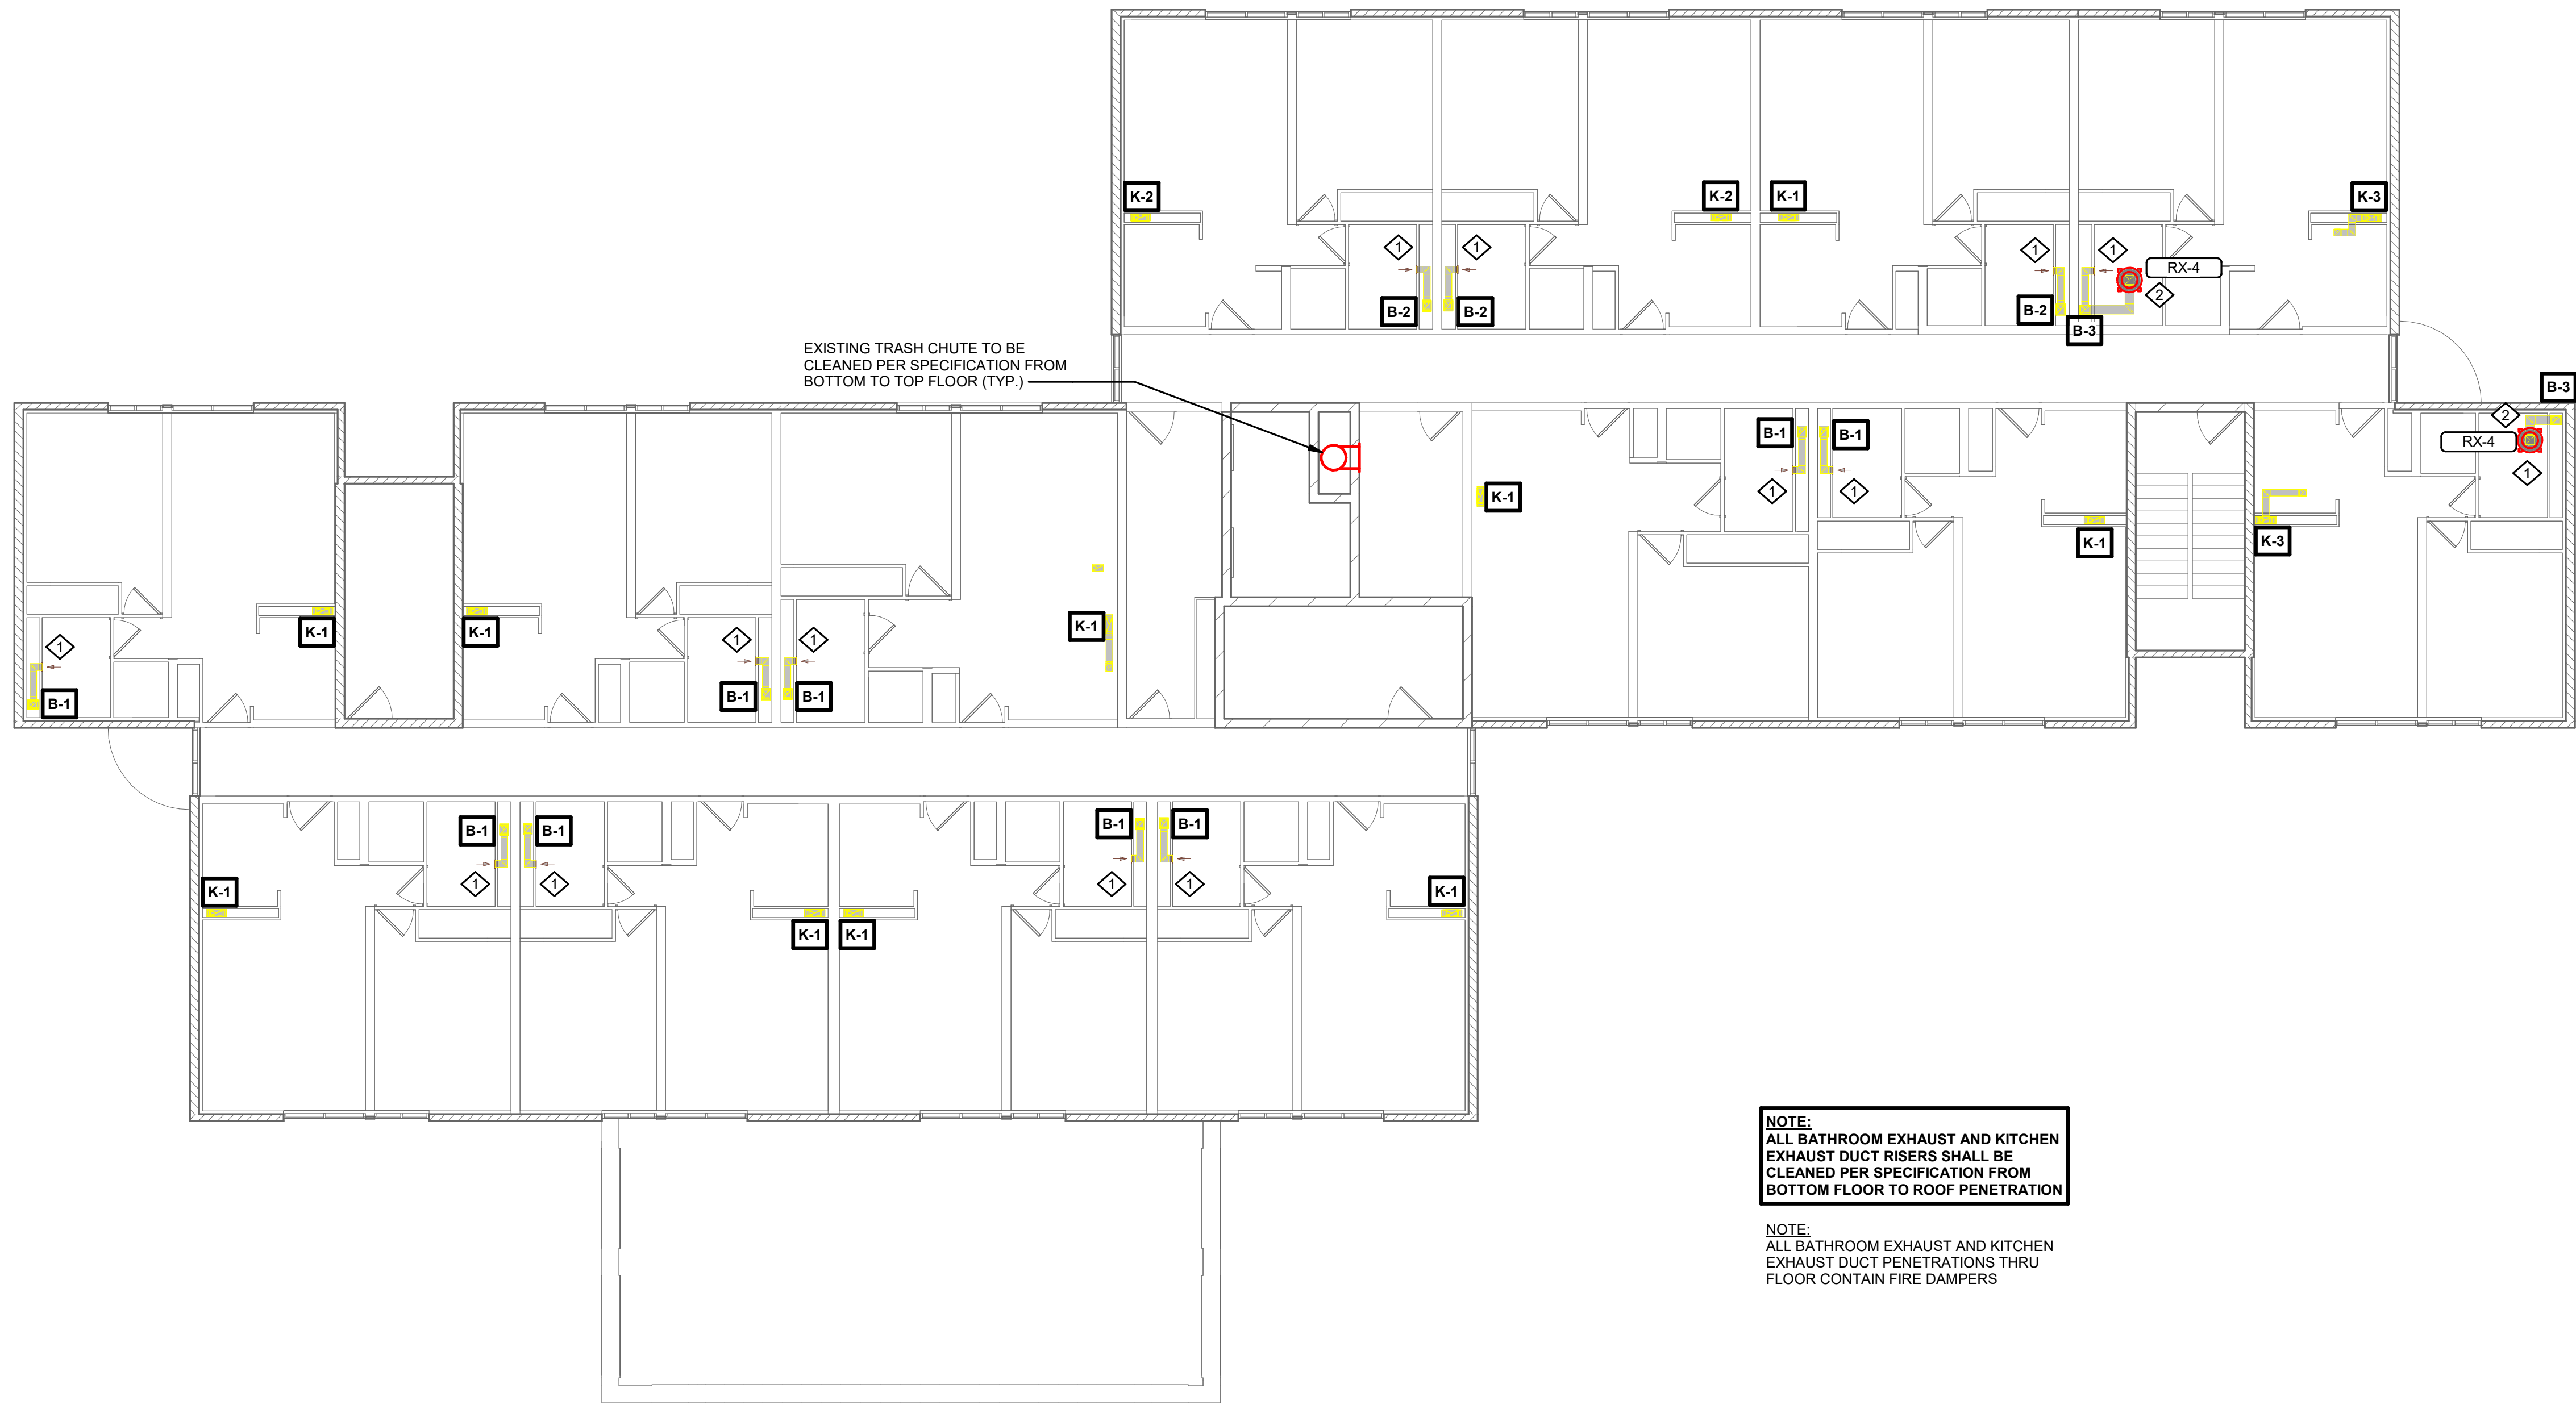


1 7TH FLOOR HVAC

1/8" = 1'-0"

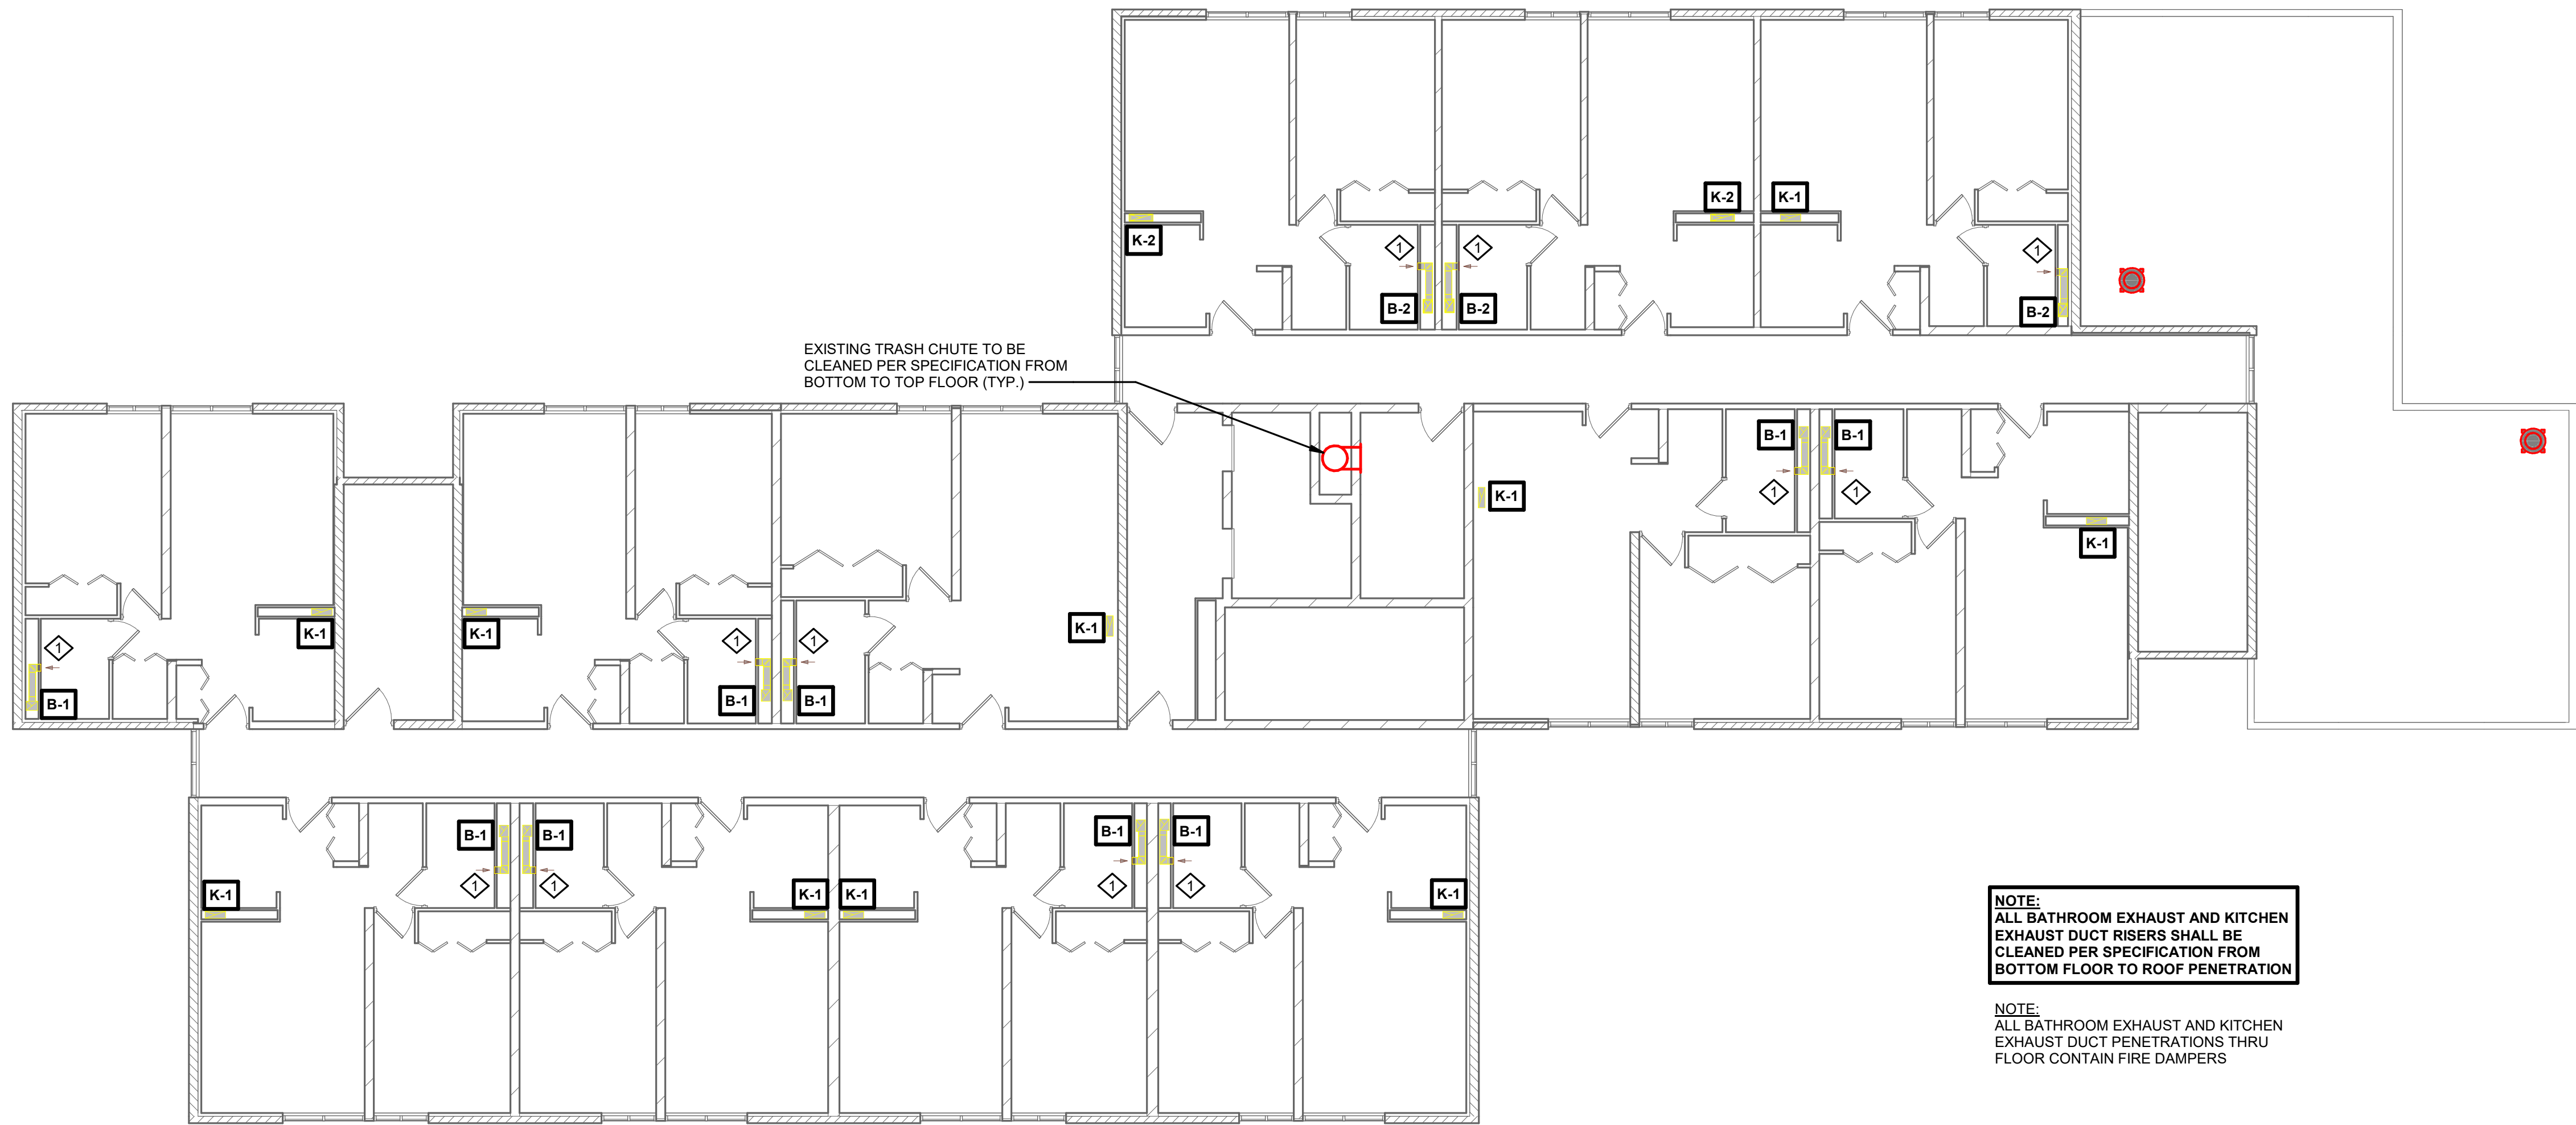


2 8TH FLOOR HVAC

1/8" = 1'-0"

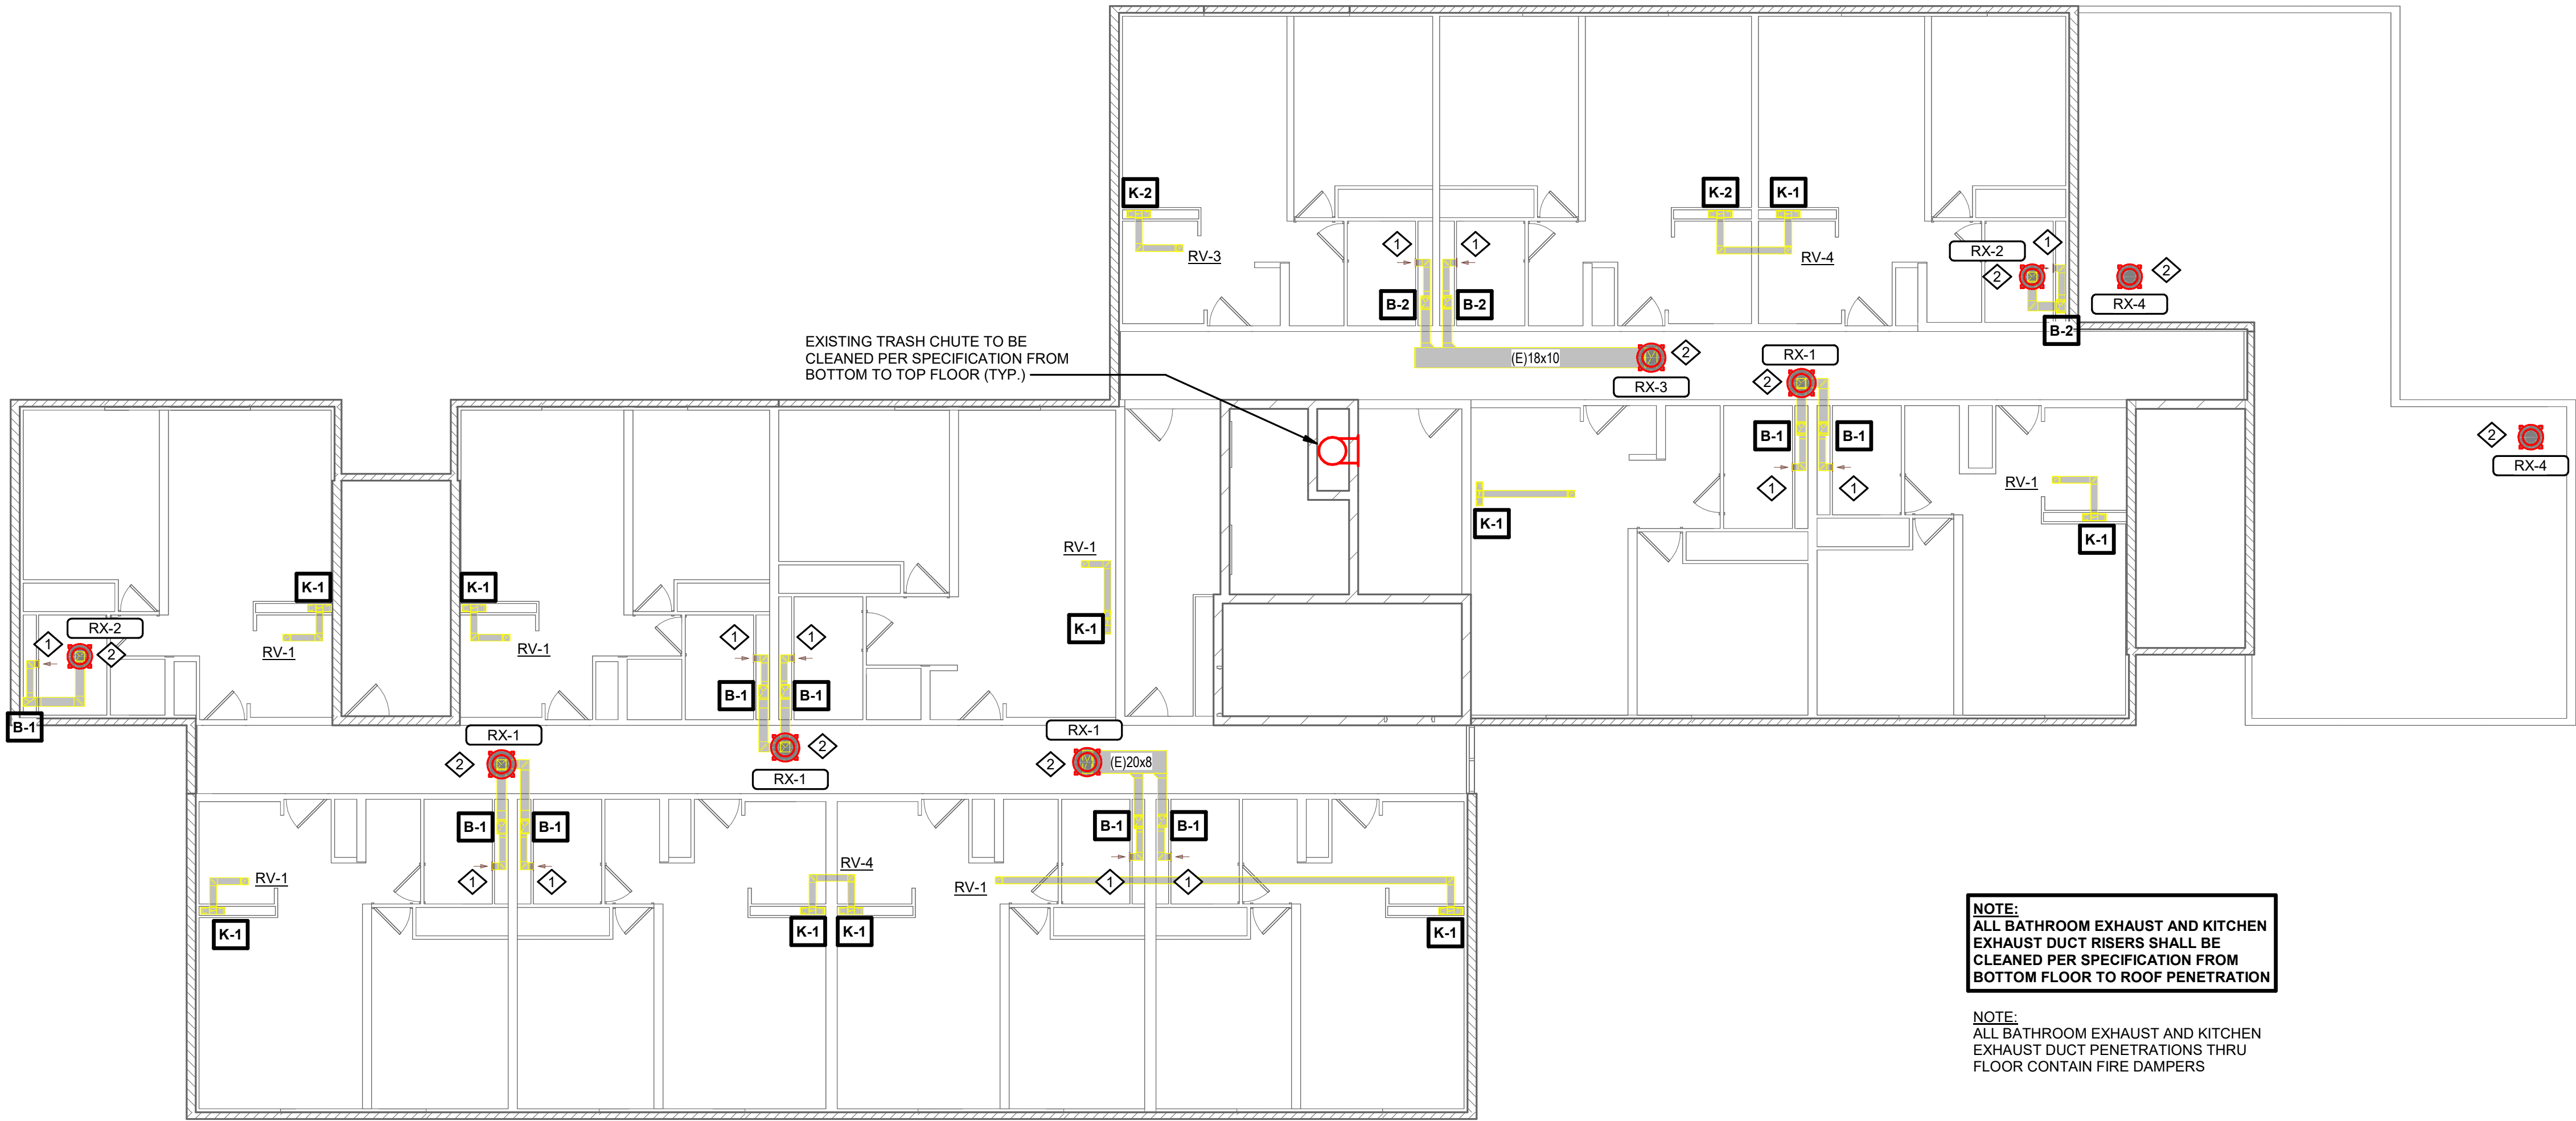


NORTH
1 9TH FLOOR HVAC
1/8" = 1'-0"

ROOF EXHAUSTER SCHEDULE																								
UNIT NO.	MANUFACTURER	MODEL NO.	SERVES	AIRFLOW	TYPE	EXHAUST FAN				MOTOR		EXHAUST AIR CONNECTOR				ROOF/WALL OPENING				ELECTRICAL				REFERENCE
						EXT. STATIC PRESS.	FAN BRAKE POWER	FAN RPM	MAX FAN RPM	DRIVE TYPE	QTY	POWER	DUCT WIDTH	DUCT HEIGHT	LENGTH	WIDTH	UNIT WEIGHT	SONES	MCA	MOP	VOLTAGE	PHASE	DETAIL NO.	
RX-1	GREENHECK	G-120-VG	B-1/B-1	1100 CFM	DOWNBLAST	1.00 in-wg	0.30 hp	1474	1800	DIRECT	1	0.50 hp	12"	12"	14 1/2"	14 1/2"	64 lbf	12.0	8 A	15 A	120 V	1	2MEP612	1. PROVIDE INSULATED 24" ATI SOUND ATTENUATING ROOF CURB. 2. PROVIDE CURB SEALS & BIRDSCREEN. 3. PROVIDE DISCONNECT SWITCH. 4. PROVIDE FACTORY MOUNTED DIAL SPEED CONTROLLER. 5. PROVIDE VFD RATED MOTOR W/ SHAFT GROUNDING. 6. PROVIDE HINGED CURB CAP KIT W/ CABLES. 7. PROVIDE GRAVITY BACKDRAFT DAMPER.
RX-2	GREENHECK	G-099-VG	B-1, B-2	700 CFM	DOWNBLAST	1.00 in-wg	0.22 hp	1664	1800	DIRECT	1	0.25 hp	12"	12"	14 1/2"	14 1/2"	54 lbf	11.0	5 A	15 A	120 V	1	2MEP612	
RX-3	GREENHECK	G-120-VG	B-2/B-2	1200 CFM	DOWNBLAST	1.00 in-wg	0.33 hp	1516	1800	DIRECT	1	0.50 hp	12"	12"	14 1/2"	14 1/2"	64 lbf	12.4	8 A	15 A	120 V	1	2MEP612	
RX-4	GREENHECK	G-098-VG	B-3	500 CFM	DOWNBLAST	1.00 in-wg	0.18 hp	1716	1800	DIRECT	1	0.25 hp	12"	12"	14 1/2"	14 1/2"	54 lbf	10.5	5 A	15 A	120 V	1	2MEP612	
Grand total: 9																								

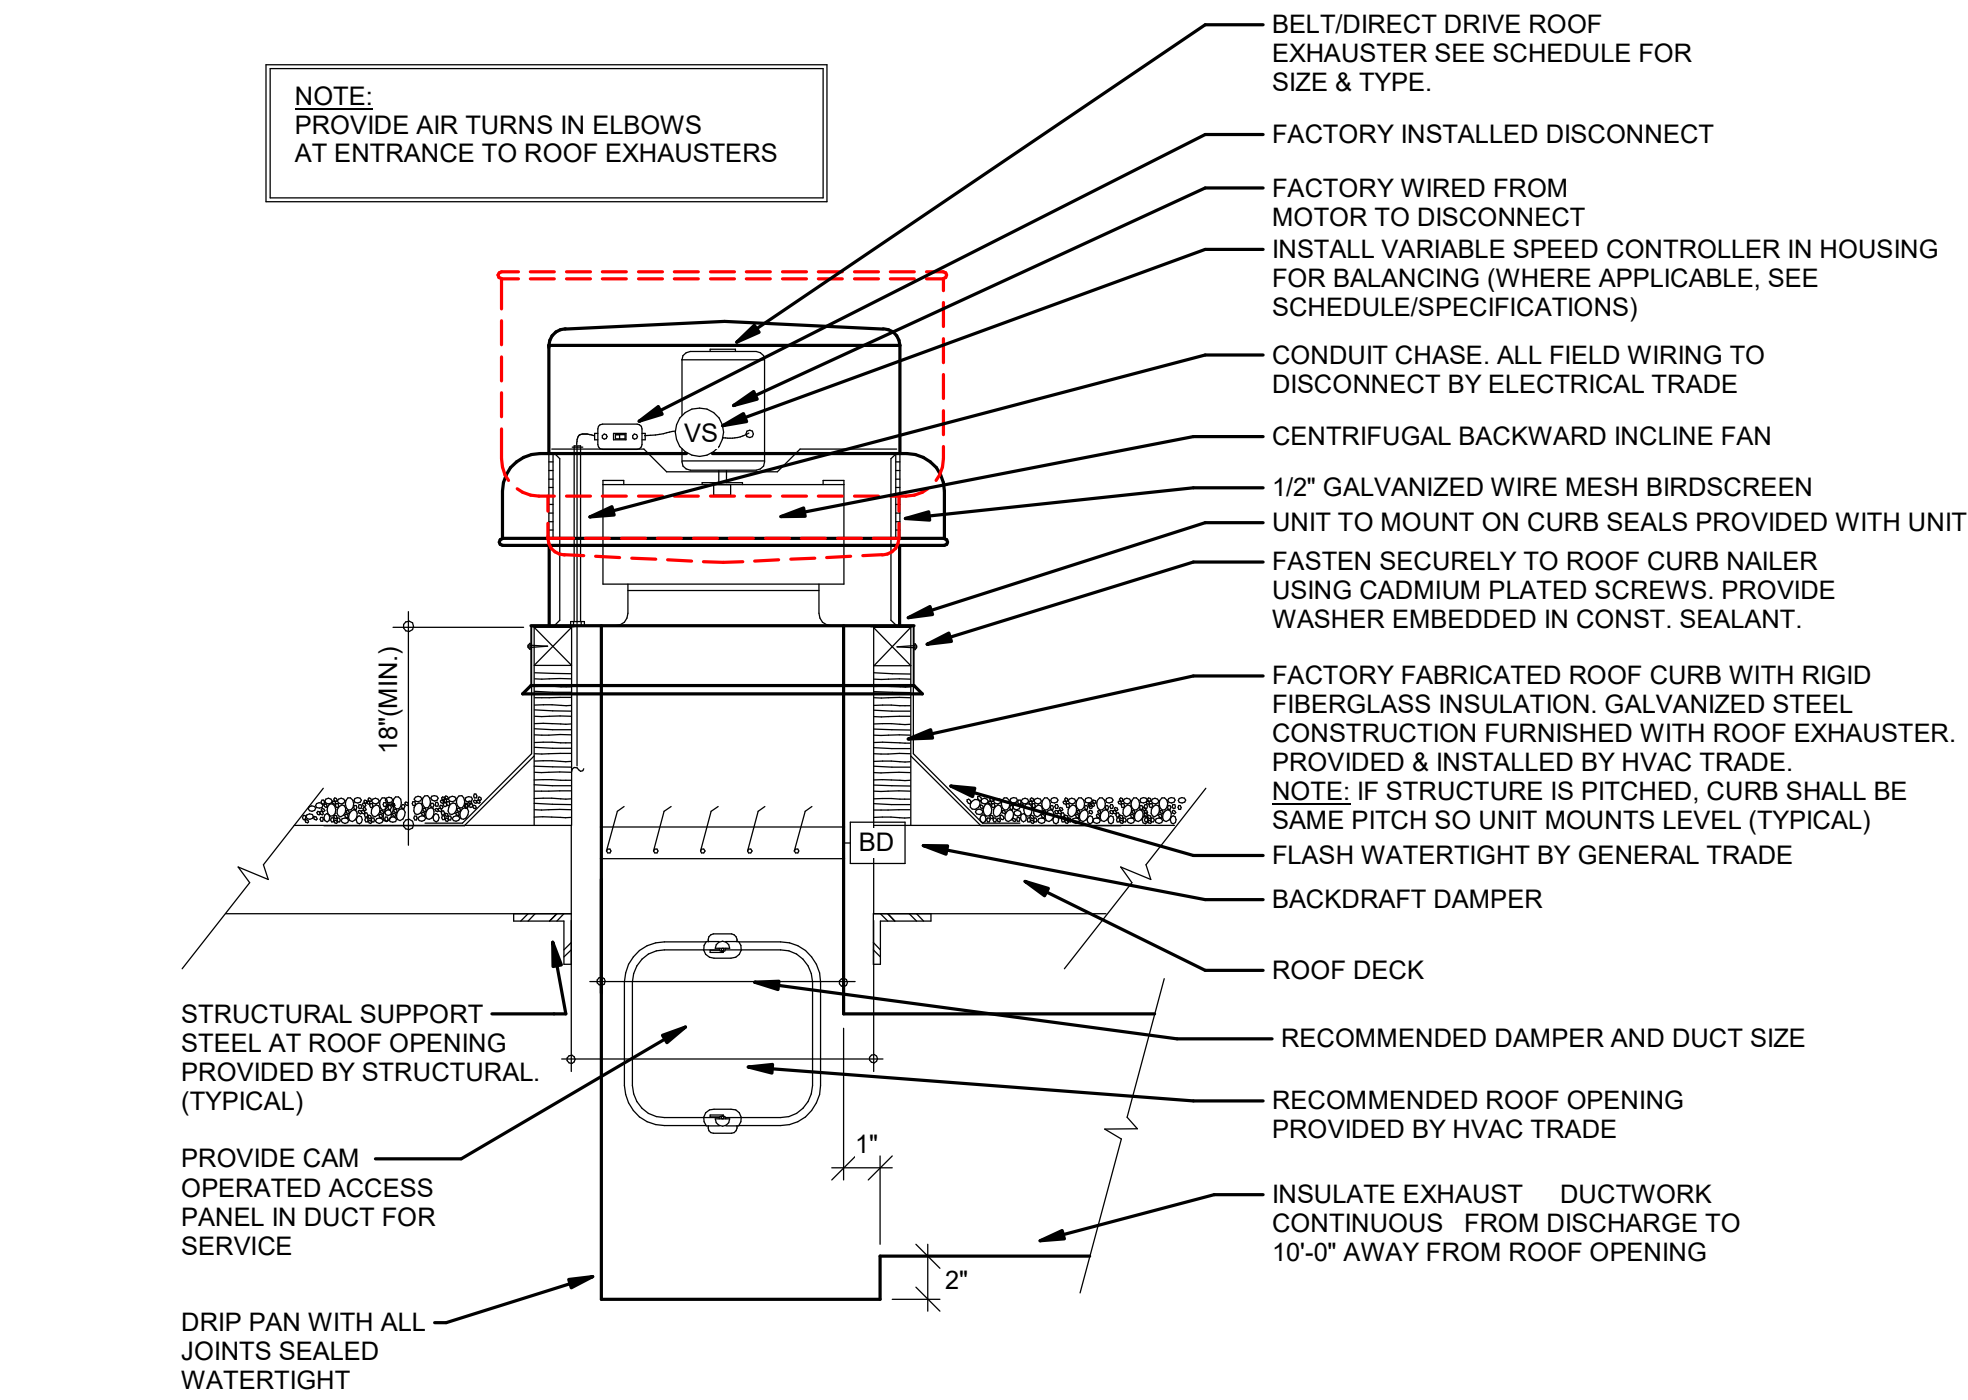

2 DOWNBLAST/UPBLAST ROOF EXHAUSTER DETAIL
1/8" = 1'-0"

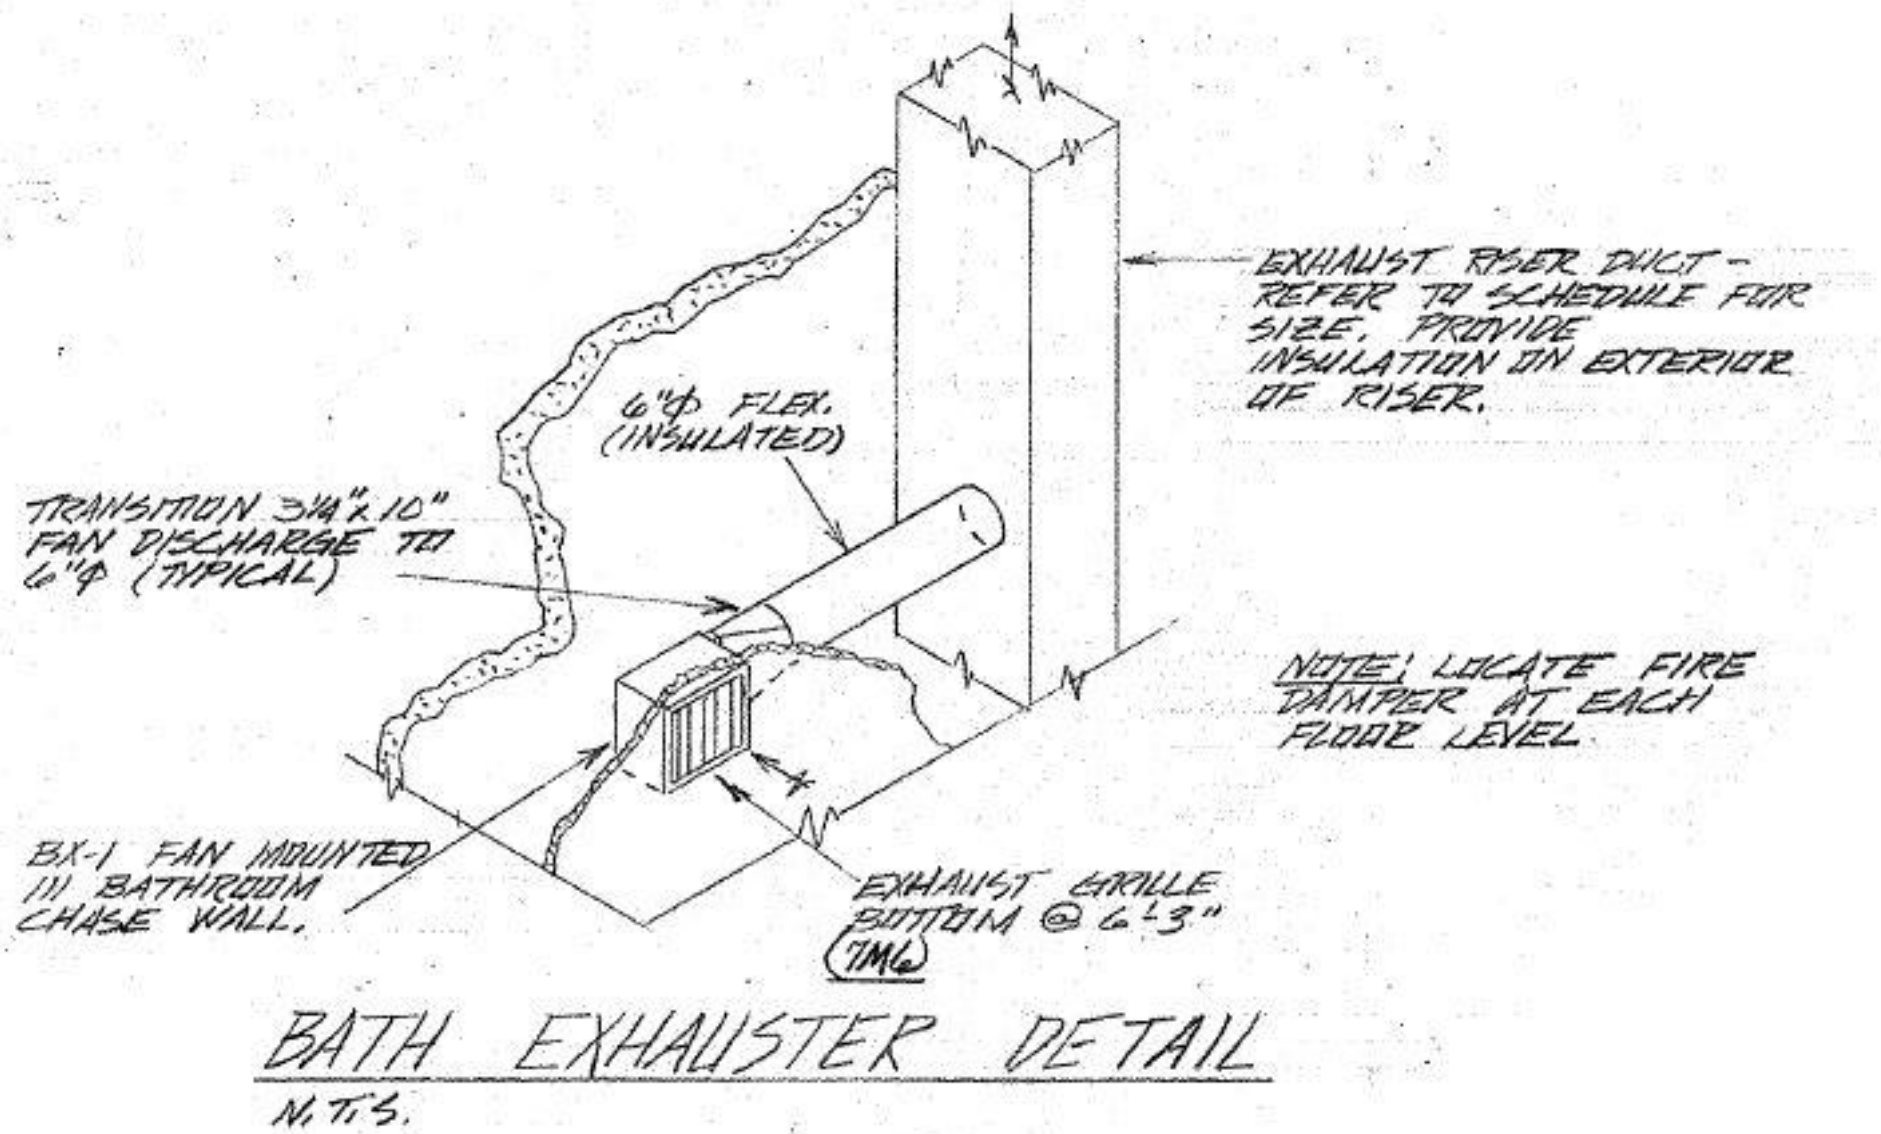

GRILLE LOCATION (FLOOR)	B-1		B-2		B-3		MAIN SUPPLY RISER S-1					
	DUCT SIZE (INSIDE) FREE AREA	C. F. M.	DUCT SIZE (INSIDE) FREE AREA	C. F. M.	DUCT SIZE (INSIDE) FREE AREA	C. F. M.	DUCT SIZE (INSIDE) FREE AREA	C. F. M.	DUCT SIZE (INSIDE) FREE AREA	C. F. M.	DUCT SIZE (INSIDE) FREE AREA	C. F. M.
1	—	—	6/6	60	6/6	60						
2	6/6	60	8/6	120	8/6	120			12x6	160		
3	8/6	120	8/6	180	8/6	180			12x6	320		
4	8/6	180	8/8	240	8/8	240			12x8	480		
5	8/8	240	8/8	300	8/8	300			12x10	640		
6	8/8	300	10/8	360	10/8	360			12x12	800		
7	10/8	360	10/8	420	10/8	420			14x12	960		
8	10/8	420	12/8	480	—	—			14x12	1120		
9	12/8	480	12/8	540	—	—			16x12	1380		

GRILLE LOCATION (FLOOR)	K-1		K-2		K-3		MAIN SUPPLY RISER S-2					
	DUCT SIZE (INSIDE) FREE AREA	C. F. M.	DUCT SIZE (INSIDE) FREE AREA	C. F. M.	DUCT SIZE (INSIDE) FREE AREA	C. F. M.	DUCT SIZE (INSIDE) FREE AREA	C. F. M.	DUCT SIZE (INSIDE) FREE AREA	C. F. M.	DUCT SIZE (INSIDE) FREE AREA	C. F. M.
1	—	—	10/4	115	10/4	115			6/6	124		
2	10/4	115	10/6	230	10/6	230			12/6	234		
3	10/6	230	12/6	345	12/6	345			12x8	444		
4	12/6	345	12/6	460	12/6	460			12x10	604		
5	12/6	460	15/6	575	15/6	575			12x12	764		
6	15/6	575	18/6	690	18/6	690			12x14	924		
7	18/6	690	18/6	805	18/6	805			12x14	1084		
8	18/6	805	24/6	920	—	—			12x16	1202		
9	24/6	920	24/6	1036	—	—			12x16	1320		

KEYNOTES - REMODEL	
Keynote Number	Keynote Description
1	COORDINATE EXACT LOCATION OF ALL CEILING MOUNTED GRILLES AND DIFFUSERS WITH CEILING GRID, SPRINKLER HEADS, RECESSED LIGHTING AND ALL OTHER CEILING MOUNTED EQUIPMENT.
1	EXISTING UNIT EXHAUST FAN TO BE REMOVED ALONG WITH ANY VOLUME DAMPERS WITHIN DUCTWORK. PROVIDE NEW BLADE STYLE EXHAUST GRILLE (WHITE ALUMINUM) TO COVER EXISTING OPENING (MECHANICAL CONTRACTOR TO FIELD VERIFY EXISTING SIZES PRIOR TO ORDER). PROVIDE NEW AUTOMATIC BALANCING DAMPER (GREENHECK ADD-T) IN BRANCH EXHAUST DUCTWORK. SET TO 60 CFM. PATCH WALL AROUND EXHAUST GRILLE AND PAINT TO MATCH EXISTING. ELECTRICAL CONTRACTOR TO DISCONNECT UNIT AND REMOVE EXISTING ELECTRICAL CIRCUIT BACK TO SOURCE. TYPICAL THOUGHTOUT PROJECT.
2	ELECTRICAL CONTRACTOR TO CONNECT NEW UNIT WITH ELECTRICAL CIRCUIT. PROVIDE 120V 20A CIRCUIT FROM NEAREST ELECTRICAL PANEL. FEEDER SIZE (2) #12 CONDUCTORS (1) #12 NEUTRAL (1) #12 GROUND 3/4" EMT CONDUIT. PROVIDE A TOGGLE SWITCH DISCONNECT FOR UNIT.

ARCHITECTURE
ENGINEERING
INTERIOR DESIGN

HSR ASSOCIATES INC.
100 MILWAUKEE STREET
LA CROSSE, WISCONSIN
PHONE: 608.784.1830
FAX: 608.782.5844
www.hsrassociates.com

HOUSING AUTHORITY OF THE CITY OF LA CROSSE
2026 CAPITAL IMPROVEMENTS PROJECTS

Project Title:
Project Location:
Sheet Title:

1307 BADGER STREET
LA CROSSE, WI 54602
FLOOR PLANS, DETAILS, AND SCHEDULES

Project Number:
Project Date:
Drawn By:

Key Plan:

BID SET

Revisions:		
No.	Description	Date

Graphic Scale:
0 2 4 6 8 12

MEP612

FOREST PARK