



HSR ASSOCIATES INC.
100 MILWAUKEE STREET
LA CROSSE, WISCONSIN
PHONE: 608.784.1830
FAX: 608.782.5844
www.hsrassociates.com

Consultant:

HOUSING AUTHORITY OF THE CITY OF LA CROSSE
2026 CAPITAL IMPROVEMENTS PROJECTS

Project Location: 1307 BADGER STREET
LA CROSSE, WI 54602

Sheet Title: FLOOR PLANS

HSR Project Number: 26039

Project Date: SEPT 24, 2026

Drawn By: JB/AB

Key Plan:


BID SET

Revisions:		
No.	Description	Date

Graphic Scale:
0 2 4 6 12


MEP710

KEYNOTES - REMODEL	
Keynote Number	Keynote Description
#	COORDINATE EXACT LOCATION OF ALL CEILING MOUNTED GRILLES AND DIFFUSERS WITH CEILING GRID, SPRINKLER HEADS, RECESSED LIGHTING AND ALL OTHER CEILING MOUNTED EQUIPMENT.
1	ELECTRICAL CONTRACTOR TO DISCONNECT UNIT AND RECONNECT NEW UNIT WITH EXISTING ELECTRICAL CIRCUIT. TYPICAL THOUGHTOUT PROJECT.

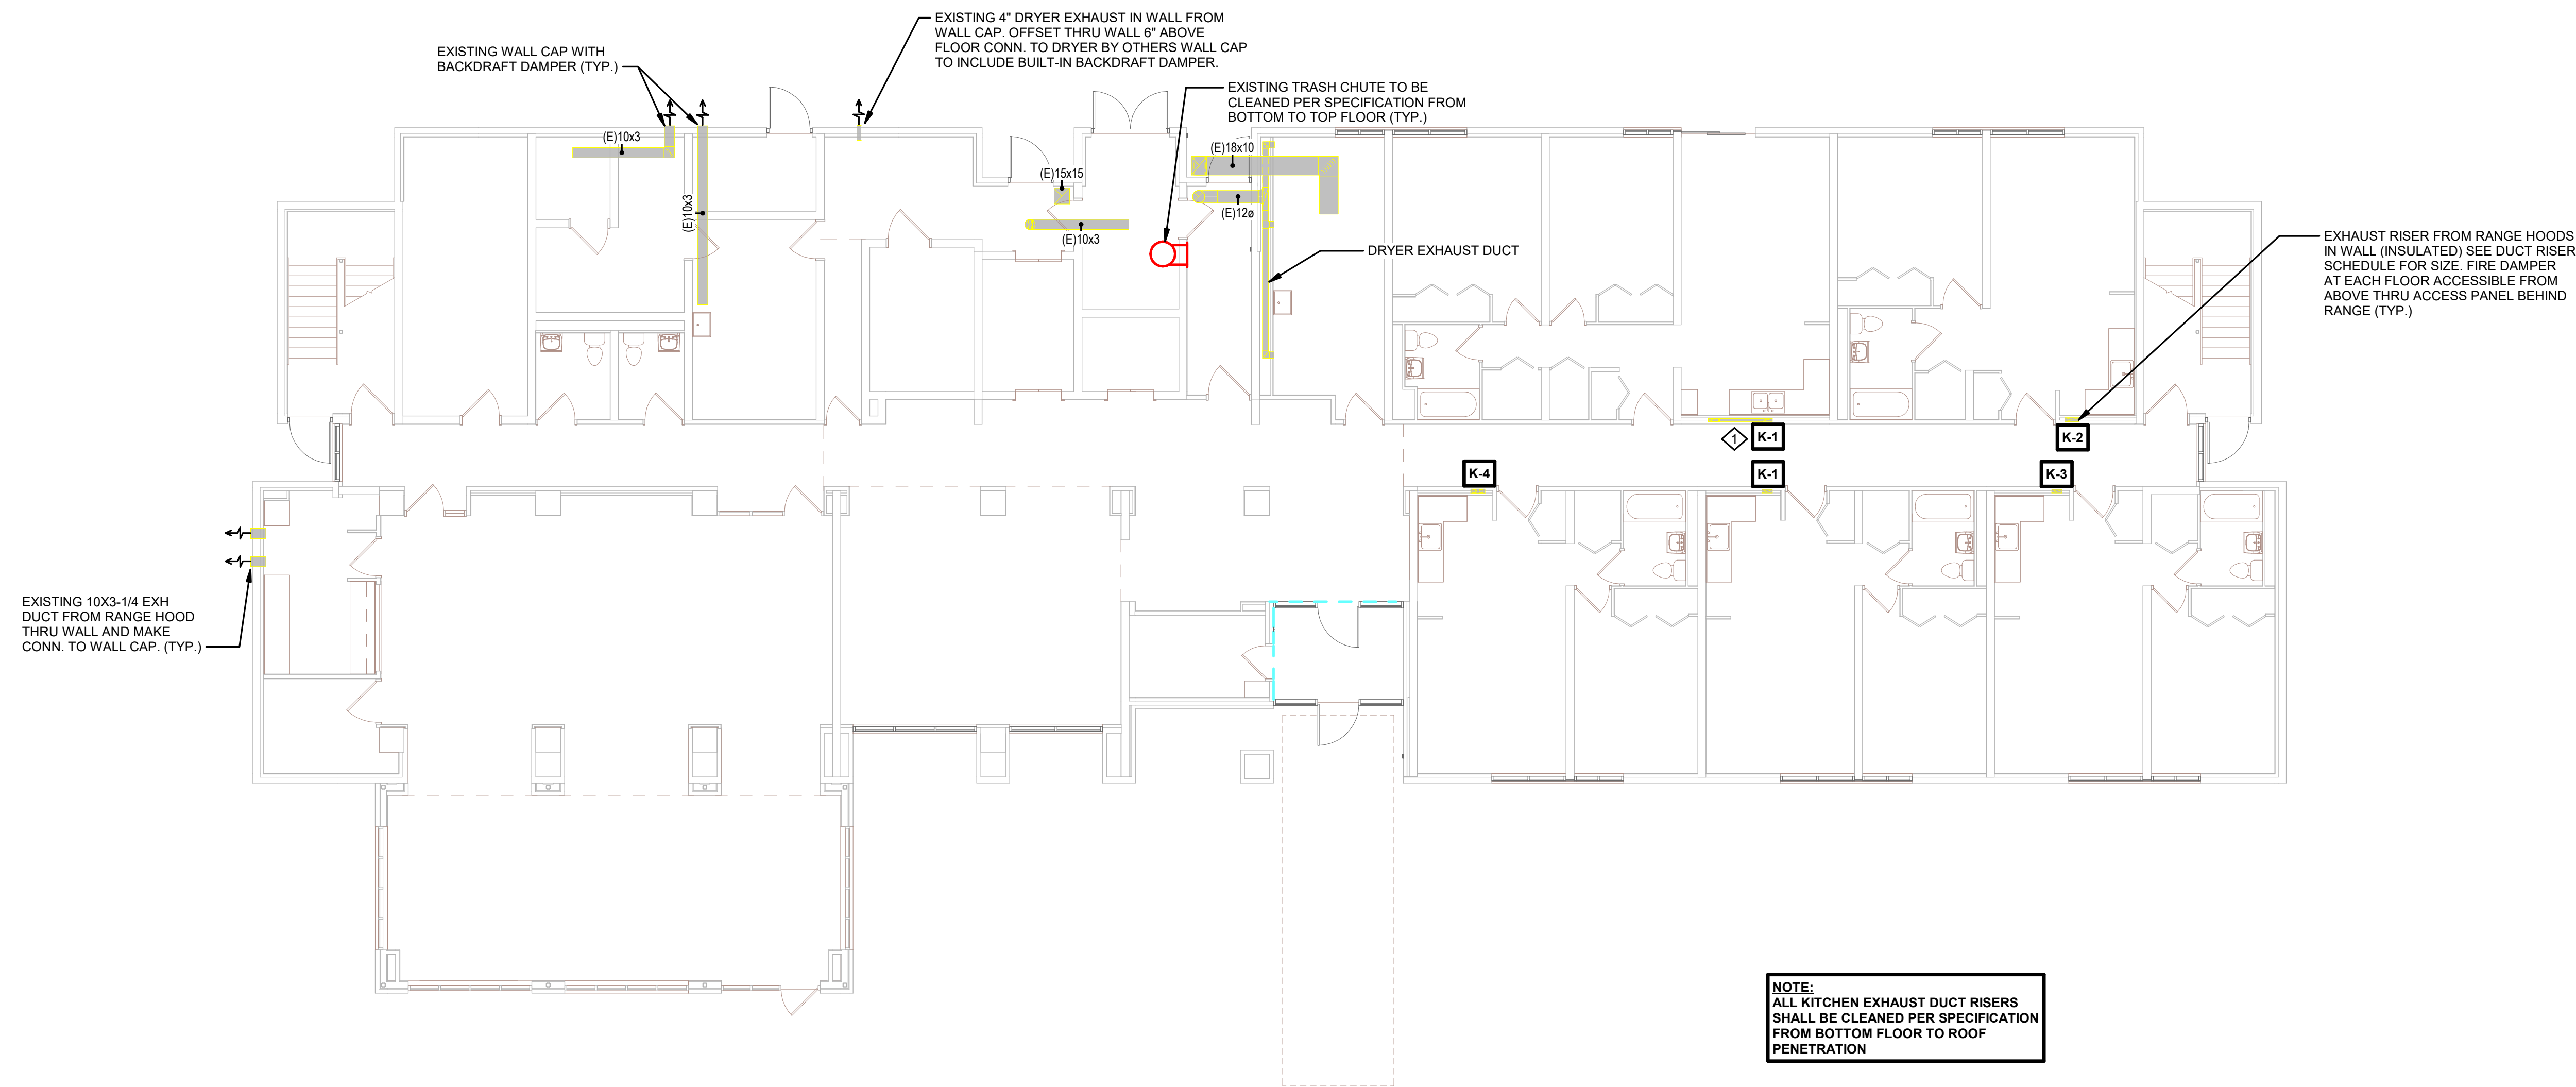

1 1ST FLOOR HVAC

1/8" = 1'-0"

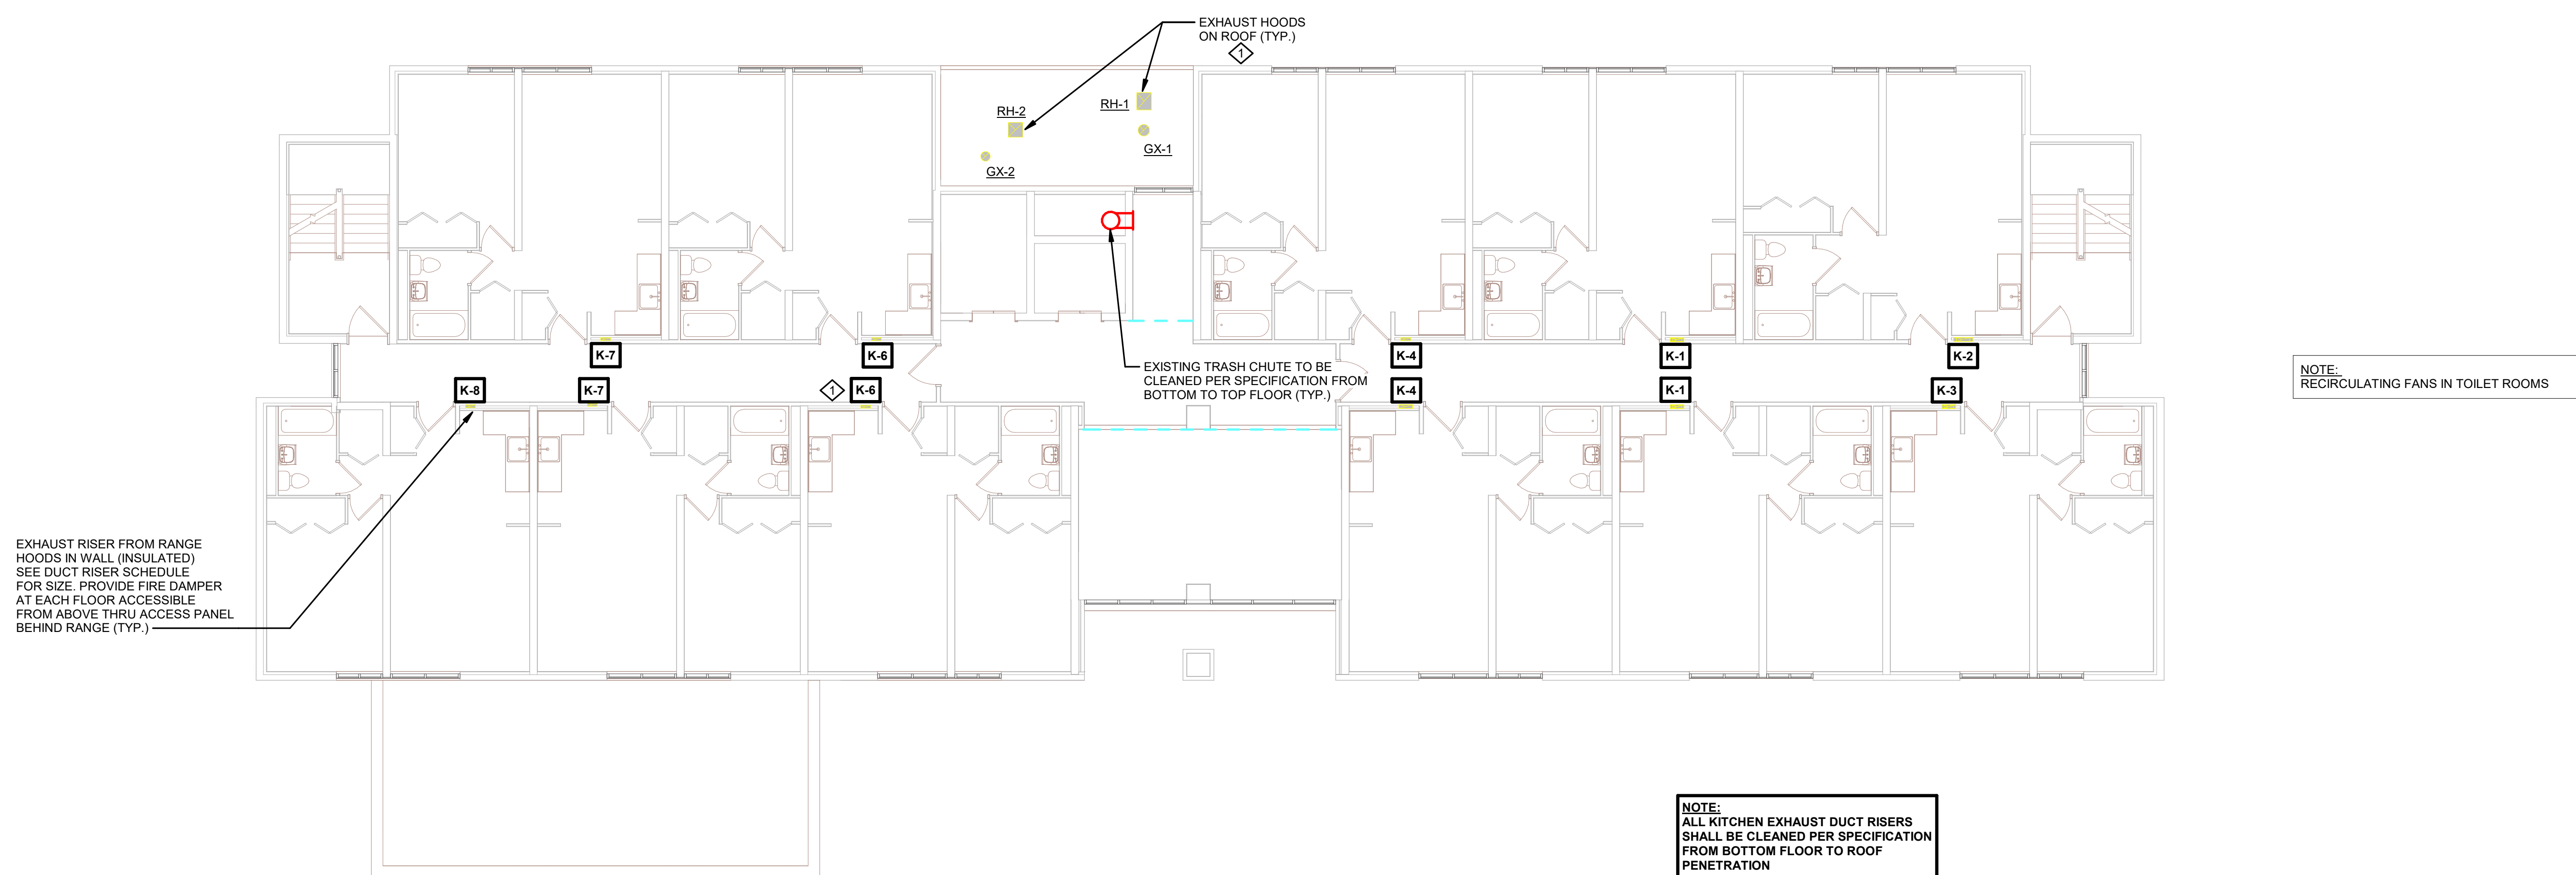


2 2ND FLOOR HVAC

1/8" = 1'-0"

PING MANOR

KEYNOTES - REMODEL	
Keynote Number	Keynote Description
#	COORDINATE EXACT LOCATION OF ALL CEILING MOUNTED GRILLES AND DIFFUSERS WITH CEILING GRID, SPRINKLER HEADS, RECESSED LIGHTING AND ALL OTHER CEILING MOUNTED EQUIPMENT.
1	ELECTRICAL CONTRACTOR TO DISCONNECT UNIT AND RECONNECT NEW UNIT WITH EXISTING ELECTRICAL CIRCUIT. TYPICAL THOUGHTOUT PROJECT.

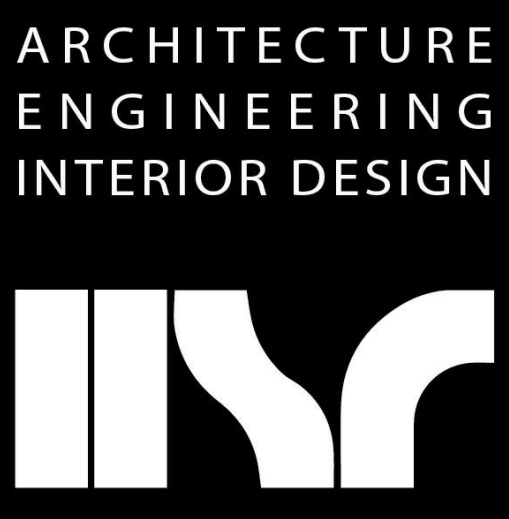

HSR ASSOCIATES INC.
100 MILWAUKEE STREET
LA CROSSE, WISCONSIN
PHONE: 608.784.1830
FAX: 608.782.5844
www.hsrassociates.com

Consultant:

HOUSING AUTHORITY OF THE CITY OF LA CROSSE
2026 CAPITAL IMPROVEMENTS PROJECTS

Project Title:

HSR Project Number:

26039

Project Date:

SEPT 24, 2026

Drawn By:

JB/AB

Key Plan:



BID SET

Revisions:		
No.	Description	Date

Graphic Scale:
0 2 4 6 12

MEP711

PING MANOR

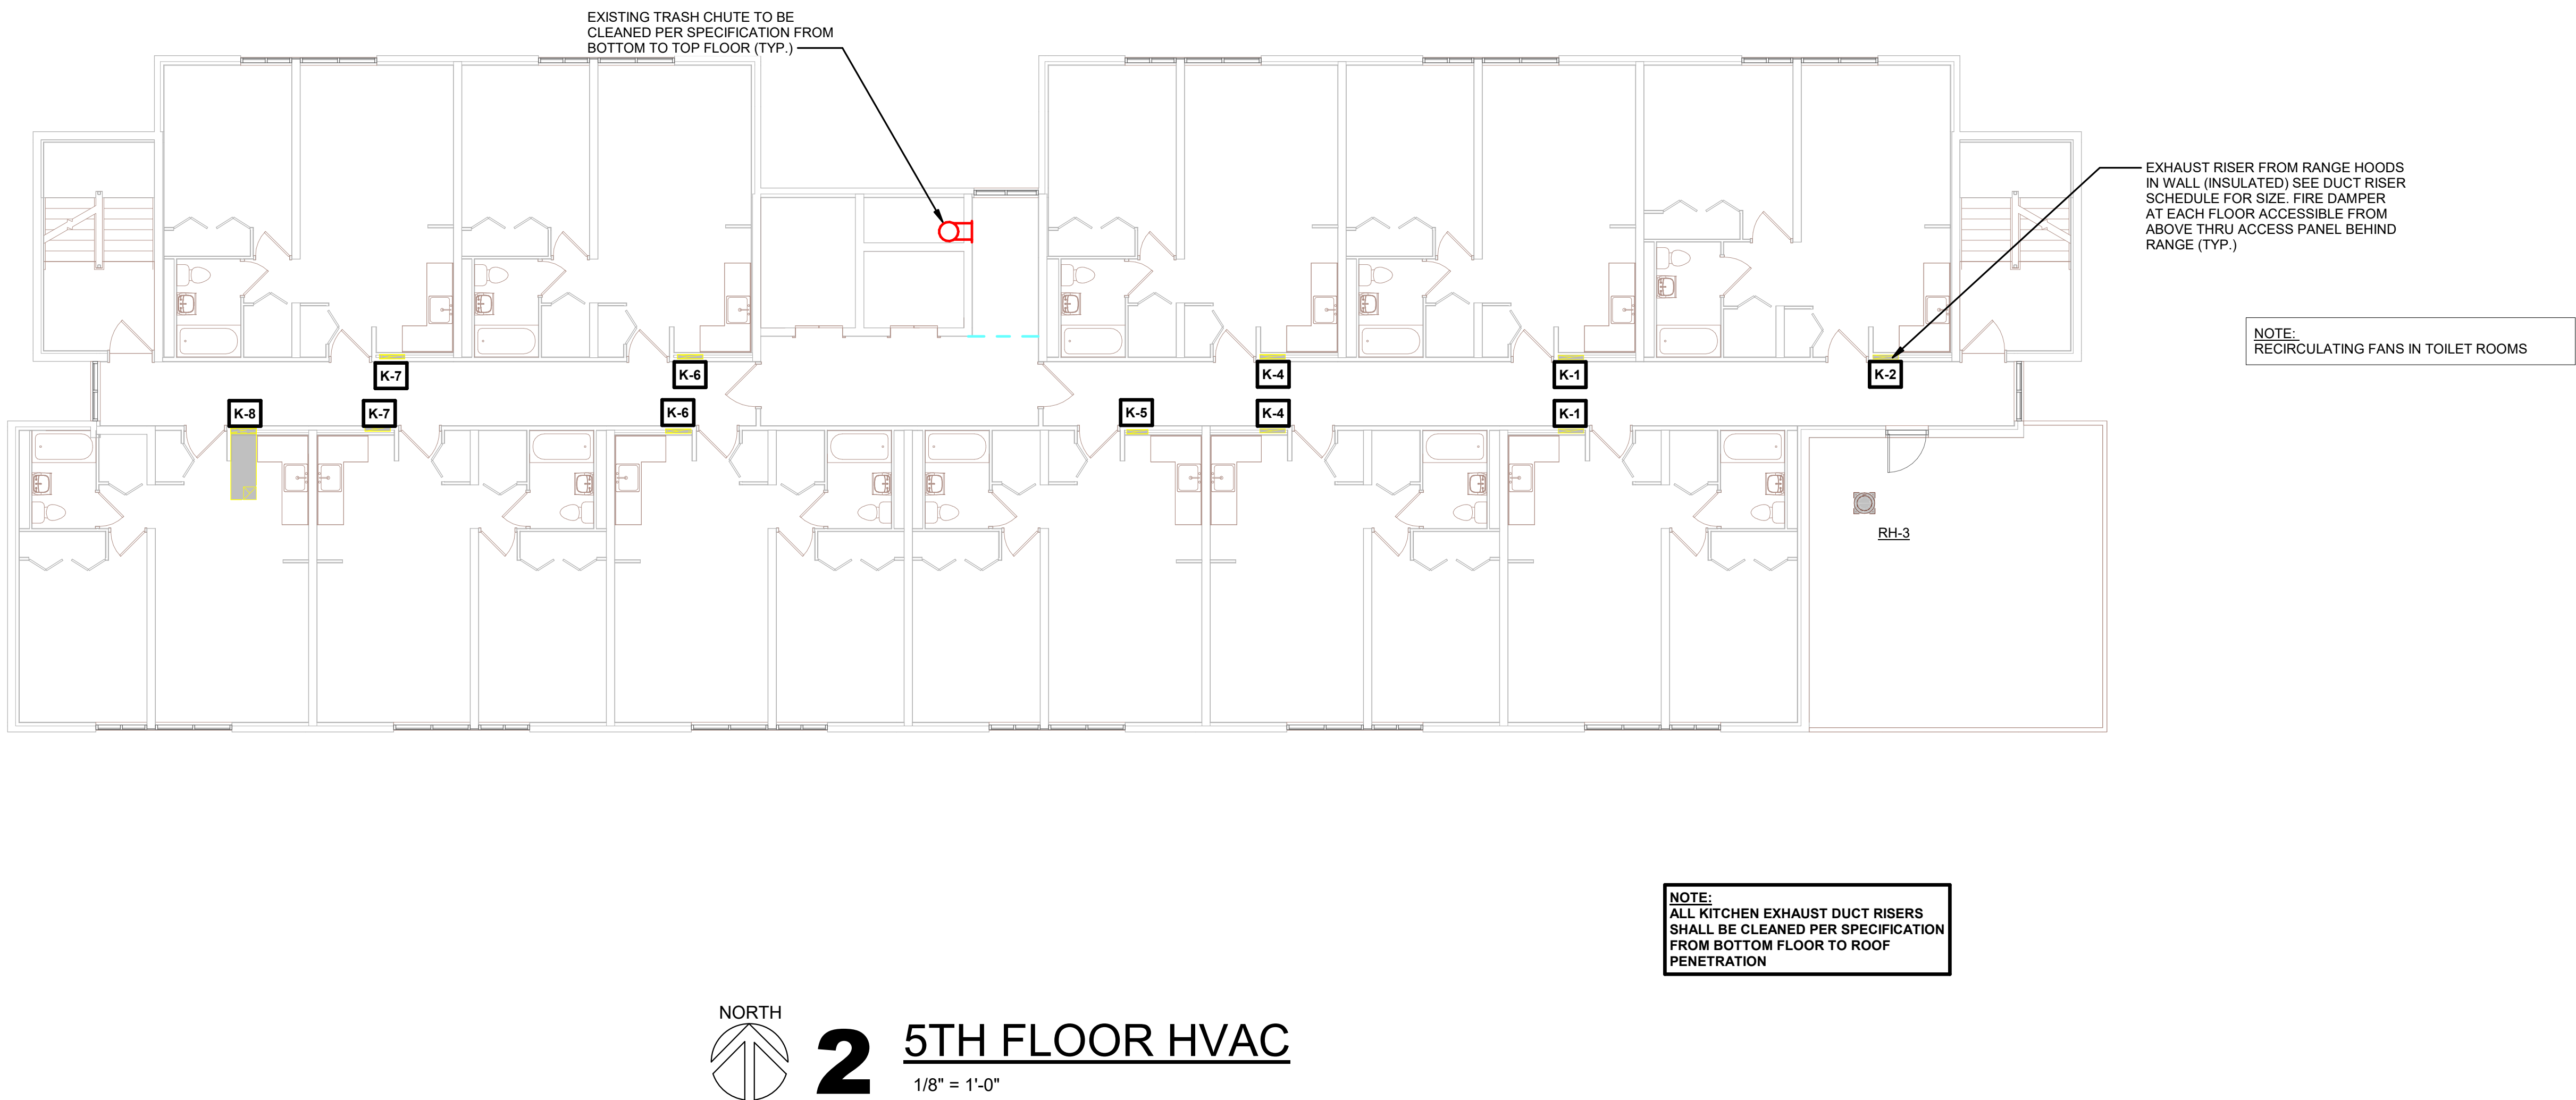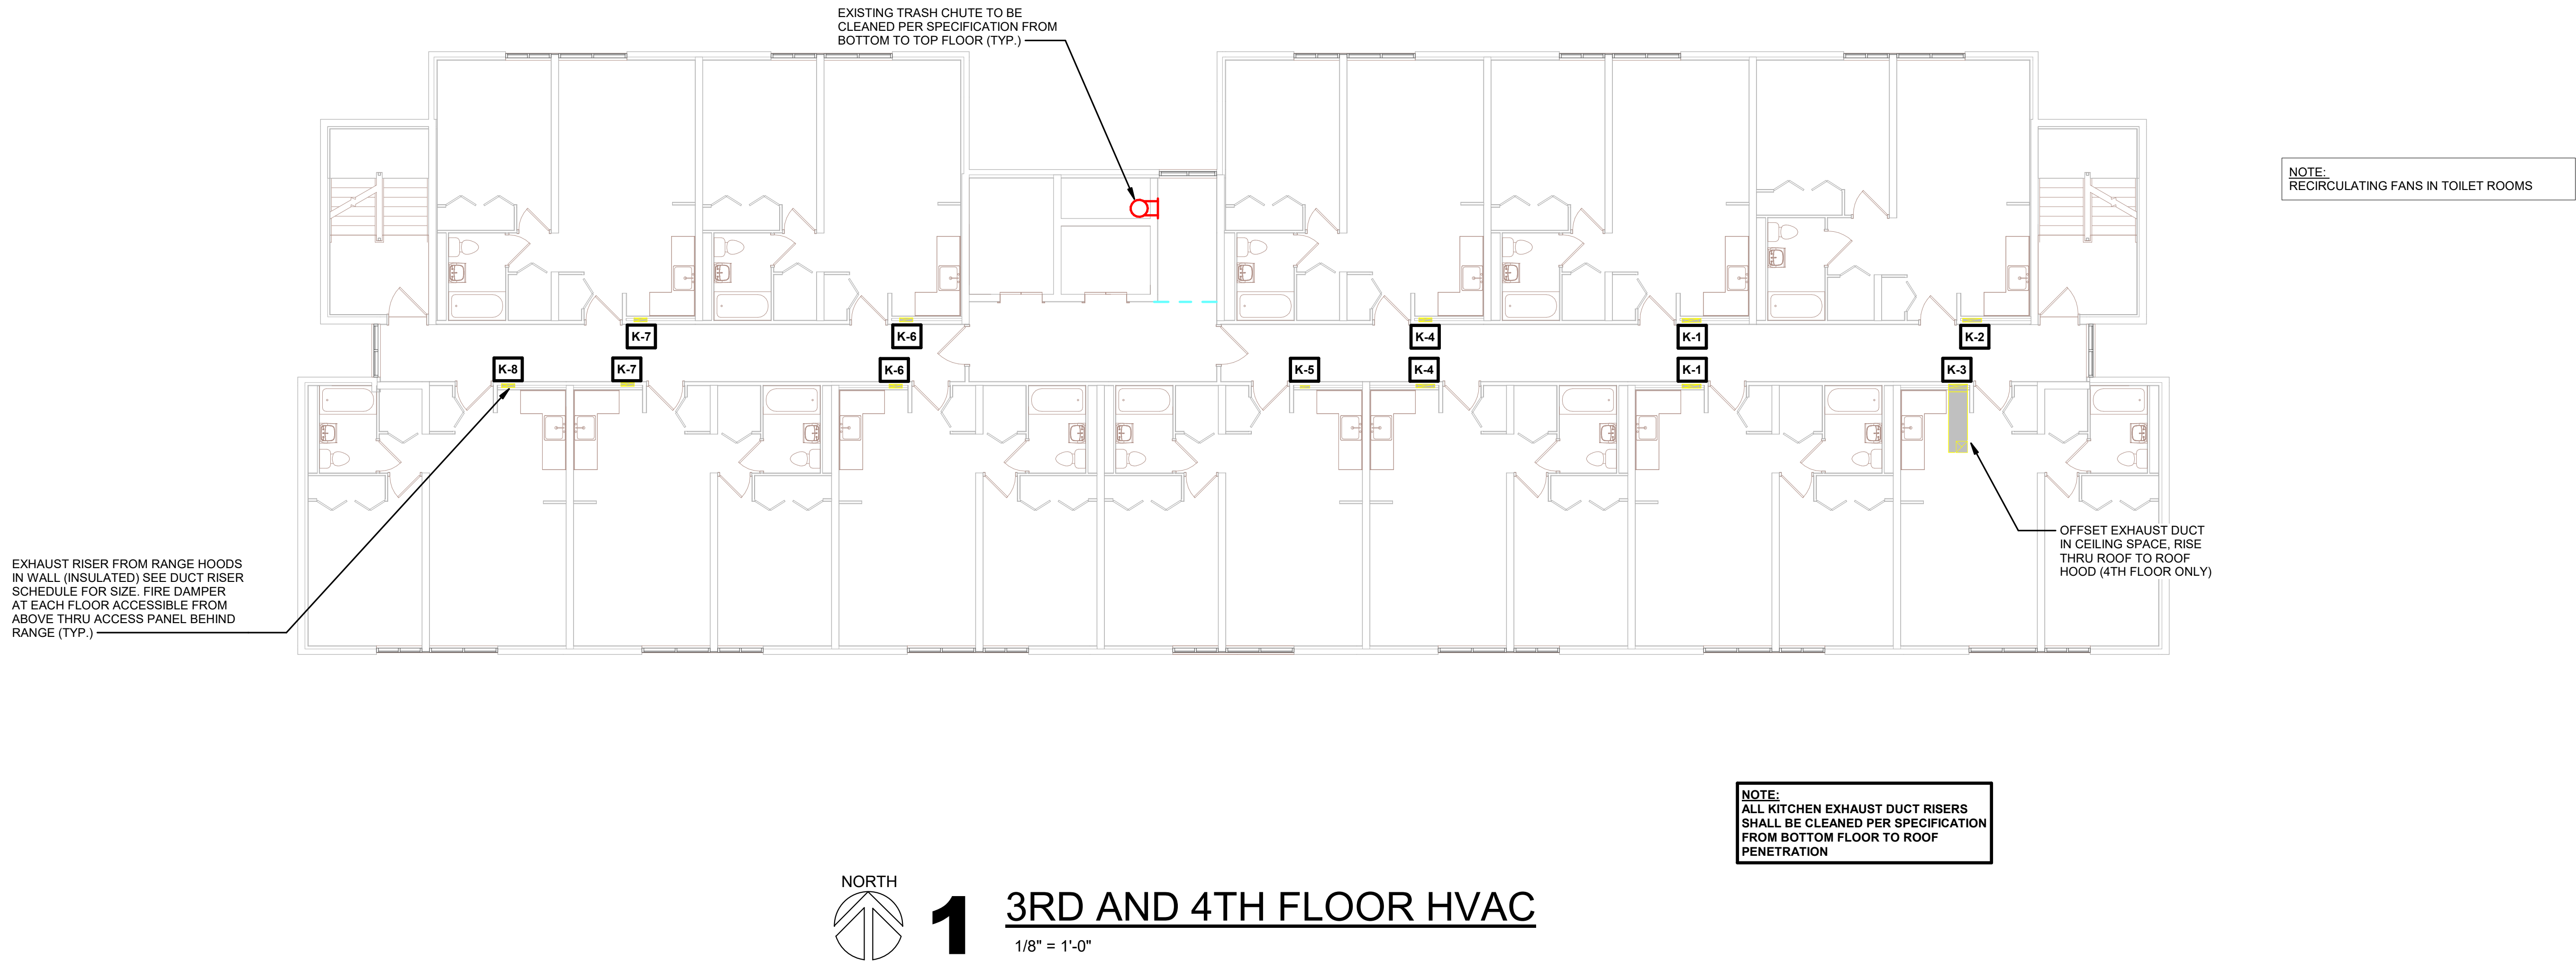

number	Keynote Description
#	COORDINATE EXACT LOCATION OF ALL CEILING MOUNTED GRILLES AND DIFFUSERS WITH CEILING GRID, SPRINKLER HEADS, RECESSED LIGHTING AND ALL OTHER CEILING MOUNTED EQUIPMENT.
1	ELECTRICAL CONTRACTOR TO DISCONNECT UNIT AND RECONNECT NEW UNIT WITH EXISTING ELECTRICAL CIRCUIT. TYPICAL THOUGHTOUT PROJECT.



NORTH

$$1/8'' = 1'-0''$$
[illegible]

Revisions:		
No.	Description	Date

Graphic Scale:



A horizontal scale bar with alternating black and white segments. The segments are labeled 0', 2', 4', 8', and 12' from left to right.

MEP712